



1					
CLIE	ENT:				
1	11/22/21	G	C. REVIEW	JVG	
	11/22/21	G.C	C. REVIEW	JvG	
N0.	DATE		REVISIONS	DRAWN	CHECKED
N0.	DATE		REVISIONS SYMBOLS Description	DRAWN	CHECKED
N0.	DATE Symbo 18'			DRAWN	CHECKED
NO.	Symbo 18'	-0"	SYMBOLS Description Ceiling Height Elev. Below Top of Steel	DRAWN	CHECKED
NO.	Symbo 18'	-0"	SYMBOLS Description Ceiling Height	DRAWN	CHECKED
NO.	Symbo 18' 	-0"	SYMBOLS Description Ceiling Height Elev. Below Top of Steel Elev. Above Finished Floor Hydraulic Reference Points Common Connection Point	DRAWN	CHECKED
NO.	Symbo 18' 	-0"	SYMBOLS Description Ceiling Height Elev. Below Top of Steel Elev. Above Finished Floor Hydraulic Reference Points	DRAWN	CHECKED
NO.	Symbo 18' 	-0"	SYMBOLS Description Ceiling Height Elev. Below Top of Steel Elev. Above Finished Floor Hydraulic Reference Points Common Connection Point Denotes Hanger Location Rise up or down Electrical Light	DRAWN	CHECKED
NO.	Symbo 18' 	-0"	SYMBOLS Description Ceiling Height Elev. Below Top of Steel Elev. Above Finished Floor Hydraulic Reference Points Common Connection Point Denotes Hanger Location Rise up or down	DRAWN	
NO.	Symbo 18' 	-0"	SYMBOLS Description Ceiling Height Elev. Below Top of Steel Elev. Above Finished Floor Hydraulic Reference Points Common Connection Point Denotes Hanger Location Rise up or down Electrical Light Room Hazard Classification	DRAWN	
NO.	Symbo 18' 	-0"	SYMBOLS Description Ceiling Height Elev. Below Top of Steel Elev. Above Finished Floor Hydraulic Reference Points Common Connection Point Denotes Hanger Location Rise up or down Electrical Light Room Hazard Classification	DRAWN	CHECKED
NO.	Symbo 18' 	-0"	SYMBOLS Description Ceiling Height Elev. Below Top of Steel Elev. Above Finished Floor Hydraulic Reference Points Common Connection Point Denotes Hanger Location Rise up or down Electrical Light Room Hazard Classification Sprinkler Head Cage	DRAWN	
NO.	Symbo 18' 		SYMBOLS Description Ceiling Height Elev. Below Top of Steel Elev. Above Finished Floor Hydraulic Reference Points Common Connection Point Denotes Hanger Location Rise up or down Electrical Light Room Hazard Classification Sprinkler Head Cage		
NO.	Symbo 18' 	-0"	SYMBOLS Description Ceiling Height Elev. Below Top of Steel Elev. Above Finished Floor Hydraulic Reference Points Common Connection Point Denotes Hanger Location Rise up or down Electrical Light Room Hazard Classification Sprinkler Head Cage	E	
NO.	Symbo 18' 		SYMBOLS Description Ceiling Height Elev. Below Top of Steel Elev. Above Finished Floor Hydraulic Reference Points Common Connection Point Denotes Hanger Location Rise up or down Electrical Light Room Hazard Classification Sprinkler Head Cage		
NO.	Symbo 18' +0' (F1 (A) (OH1 (C)		SYMBOLS Description Ceiling Height Elev. Below Top of Steel Elev. Above Finished Floor Hydraulic Reference Points Common Connection Point Denotes Hanger Location Rise up or down Electrical Light Room Hazard Classification Sprinkler Head Cage	E	
NO.	Symbo 18' 		SYMBOLS Description Ceiling Height Elev. Below Top of Steel Elev. Above Finished Floor Hydraulic Reference Points Common Connection Point Denotes Hanger Location Rise up or down Electrical Light Room Hazard Classification Sprinkler Head Cage	E	
			SYMBOLS Description Ceiling Height Elev. Below Top of Steel Elev. Above Finished Floor Hydraulic Reference Points Common Connection Point Denotes Hanger Location Rise up or down Electrical Light Room Hazard Classification Sprinkler Head Cage N Sprinkler Head Cage	E 16' 18'	
		-0"	SYMBOLS Description Ceiling Height Elev. Below Top of Steel Elev. Above Finished Floor Hydraulic Reference Points Common Connection Point Denotes Hanger Location Rise up or down Electrical Light Room Hazard Classification Sprinkler Head Cage N Sprinkler Head Cage A d' d' 8' 10' 12' 14 FIRE SPRINKLE	E 	S FOR
			SYMBOLS Description Ceiling Height Elev. Below Top of Steel Elev. Above Finished Floor Hydraulic Reference Points Common Connection Point Denotes Hanger Location Rise up or down Electrical Light Room Hazard Classification Sprinkler Head Cage N Sprinkler Head Cage A' 6' 8' 10' 12' 14 FIRE SPRINKLE SSSWINI	E ' 16' 18' ER PLAN DS I	S FOR
			SYMBOLS Description Ceiling Height Elev. Below Top of Steel Elev. Above Finished Floor Hydraulic Reference Points Common Connection Point Denotes Hanger Location Rise up or down Electrical Light Room Hazard Classification Sprinkler Head Cage N Sprinkler Head Cage A d' d' 8' 10' 12' 14 FIRE SPRINKLE	E ' 16' 18' ER PLAN DS I	S FOR
PRO			SYMBOLS Description Ceiling Height Elev. Below Top of Steel Elev. Above Finished Floor Hydraulic Reference Points Common Connection Point Denotes Hanger Location Rise up or down Electrical Light Room Hazard Classification Sprinkler Head Cage N A S S S S S S S S S S S S S	E ' 16' 18' ER PLAN DS I	S FOR
PRO			SYMBOLS Description Ceiling Height Elev. Below Top of Steel Elev. Above Finished Floor Hydraulic Reference Points Common Connection Point Denotes Hanger Location Rise up or down Electrical Light Room Hazard Classification Sprinkler Head Cage N A S S S S S S S S S S S S S	E ' 16' 18' ER PLAN DS I	S FOR
PRO			SYMBOLS Description Ceiling Height Elev. Below Top of Steel Elev. Above Finished Floor Hydraulic Reference Points Common Connection Point Denotes Hanger Location Rise up or down Electrical Light Room Hazard Classification Sprinkler Head Cage N A S S S S S S S S S S S S S	E ' 16' 18' ER PLAN DS I	S FOR
PRO			SYMBOLS Description Ceiling Height Elev. Below Top of Steel Elev. Above Finished Floor Hydraulic Reference Points Common Connection Point Denotes Hanger Location Rise up or down Electrical Light Room Hazard Classification Sprinkler Head Cage N A S S S S S S S S S S S S S	E ' 16' 18' ER PLAN DS I	S FOR
PRO			SYMBOLS Description Ceiling Height Elev. Below Top of Steel Elev. Above Finished Floor Hydraulic Reference Points Common Connection Point Denotes Hanger Location Rise up or down Electrical Light Room Hazard Classification Sprinkler Head Cage N A S S S S S S S S S S S S S	E 16' 18' ER PLAN DS I	S FOR
PRO			SYMBOLS Description Ceiling Height Elev. Below Top of Steel Elev. Above Finished Floor Hydraulic Reference Points Common Connection Point Denotes Hanger Location Rise up or down Electrical Light Room Hazard Classification Sprinkler Head Cage N A S S S S S S S S S S S S S	E 16' 18' ER PLAN DS I	S FOR
PRO			SYMBOLS Description Ceiling Height Elev. Below Top of Steel Elev. Above Finished Floor Hydraulic Reference Points Common Connection Point Denotes Hanger Location Rise up or down Electrical Light Room Hazard Classification Sprinkler Head Cage N A S S S S S S S S S S S S S	E 16' 18' ER PLAN DS I	S FOR
PRO			SYMBOLS Description Ceiling Height Elev. Below Top of Steel Elev. Above Finished Floor Hydraulic Reference Points Common Connection Point Denotes Hanger Location Rise up or down Electrical Light Room Hazard Classification Sprinkler Head Cage N A S S S S S S S S S S S S S	E 16' 18' ER PLAN DS I	S FOR
PRO			SYMBOLS Description Ceiling Height Elev. Below Top of Steel Elev. Above Finished Floor Hydraulic Reference Points Common Connection Point Denotes Hanger Location Rise up or down Electrical Light Room Hazard Classification Sprinkler Head Cage N A S S S S S S S S S S S S S	E 16' 18' ER PLAN DS I	S FOR
PRO			SYMBOLS Description Ceiling Height Elev. Below Top of Steel Elev. Above Finished Floor Hydraulic Reference Points Common Connection Point Denotes Hanger Location Rise up or down Electrical Light Room Hazard Classification Sprinkler Head Cage N A S S S S S S S S S S S S S	E T T T T T T T T T T T T T T T T T T T	
			SYMBOLS Description Ceiling Height Elev. Below Top of Steel Elev. Above Finished Floor Hydraulic Reference Points Common Connection Point Denotes Hanger Location Rise up or down Electrical Light Room Hazard Classification Sprinkler Head Cage N A C SPRINKLER SPRINKLER SPRINKLER	E T T T T T T T T T T T T T T T T T T T	
			SYMBOLS Description Ceiling Height Elev. Below Top of Steel Elev. Above Finished Floor Hydraulic Reference Points Common Connection Point Denotes Hanger Location Rise up or down Electrical Light Room Hazard Classification Sprinkler Head Cage N A C SPRINKLER SPRINKLER SPRINKLER SPRINKLER SPRINKLER SPRINKLER	E T T T T T T T T T T T T T T T T T T T	

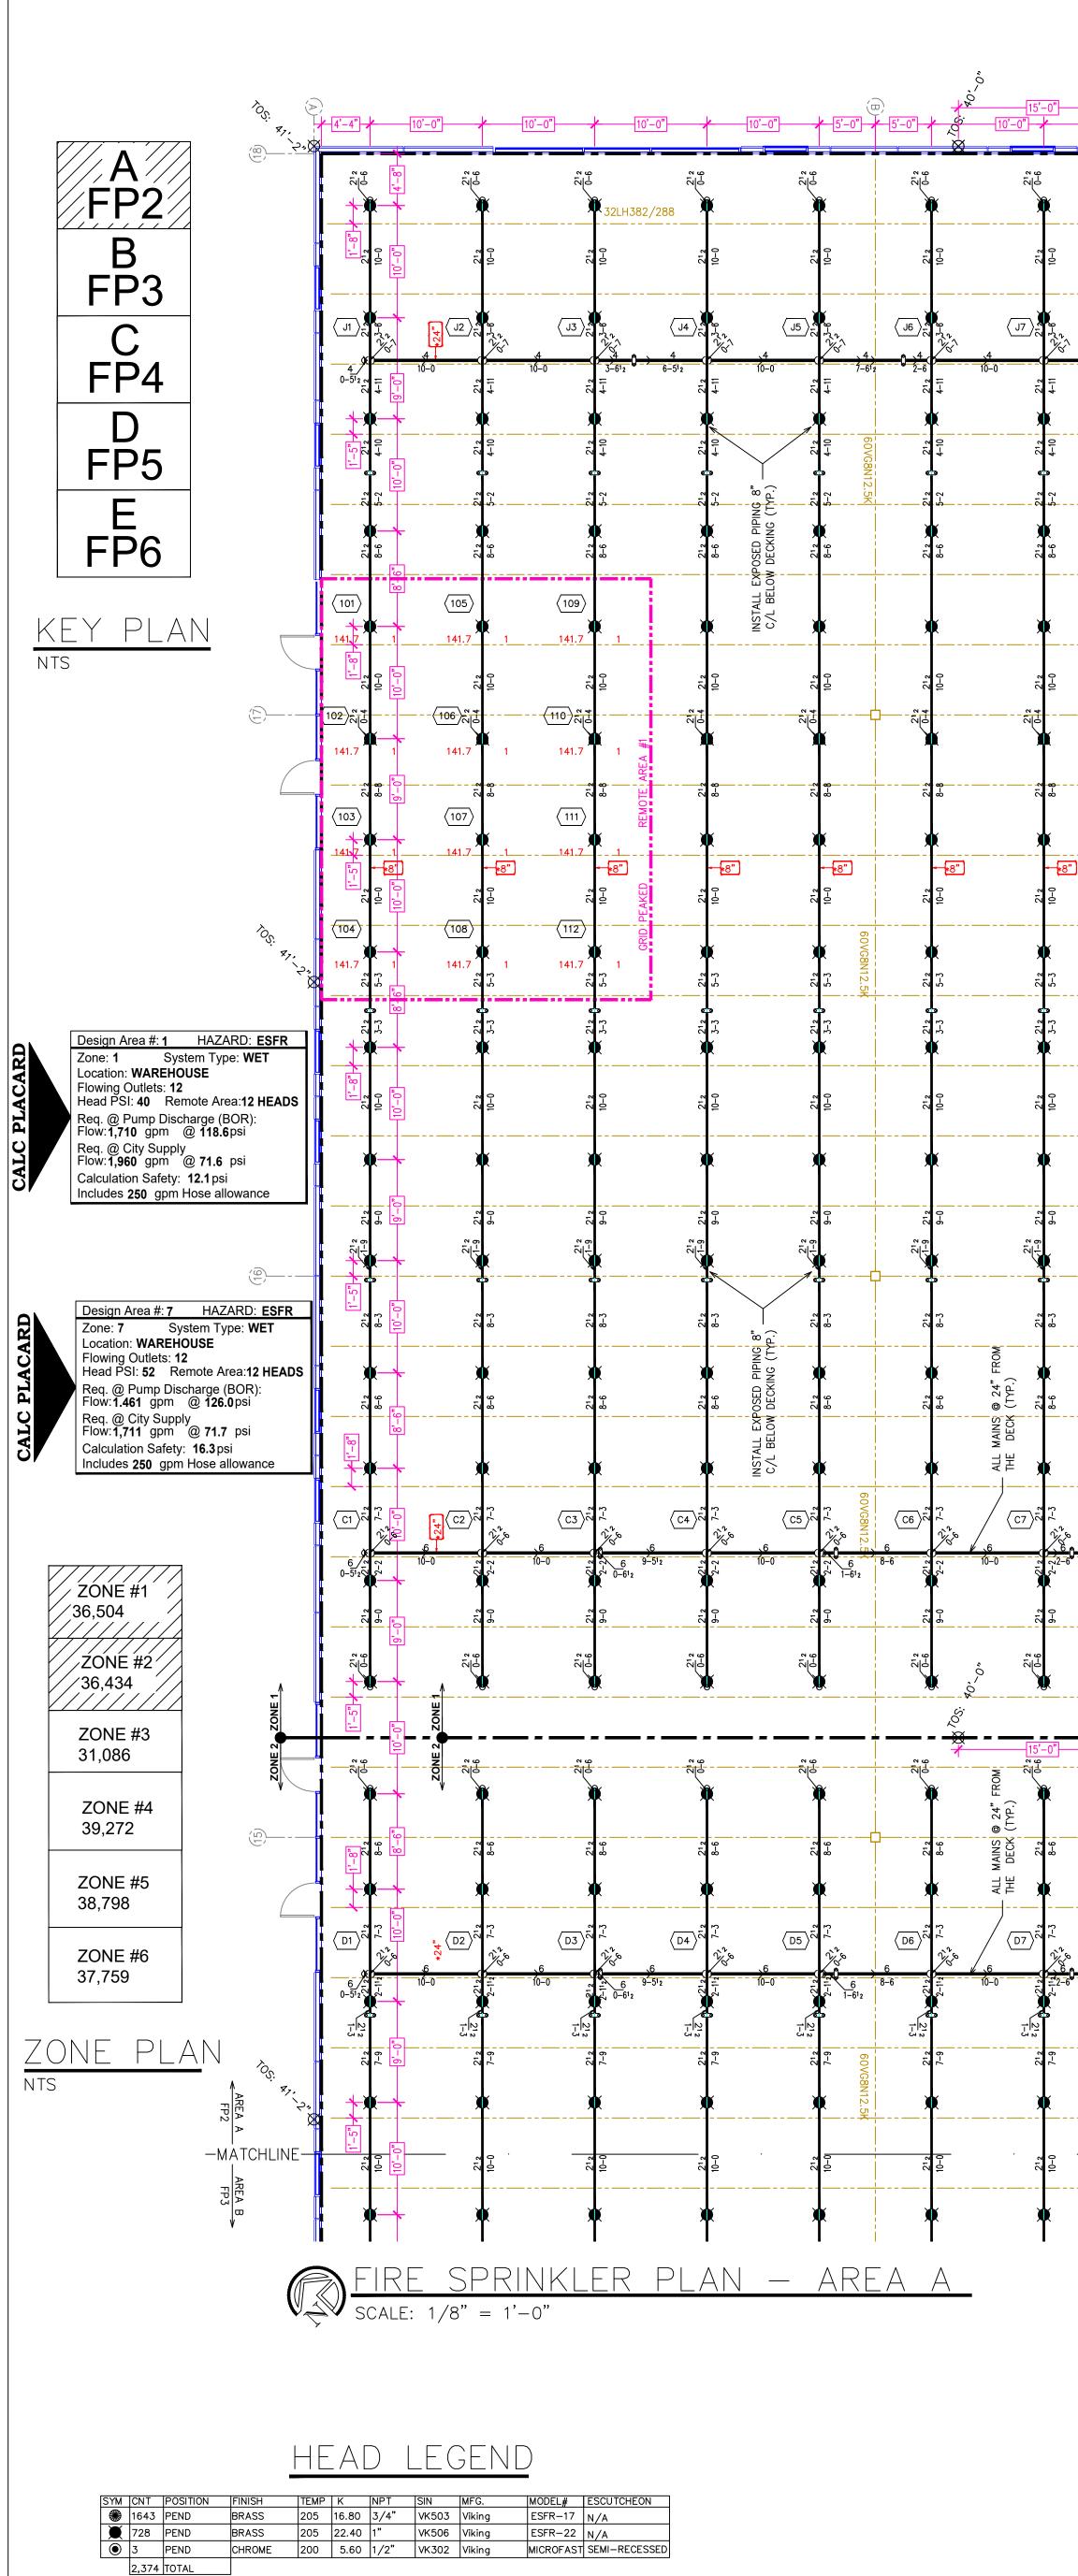


PER NFPA 13 TABLES 14.4.1, 15.4.1, 16.3.3.1 & 17.3.3.1 IN AREAS WITH A DECK HEIGHT OF OVER 40'-0" THE USE OF 16.8K SPRINKLERS IS PROHIBITED AS WELL AS THE STORAGE OF EXPOSED UNEXPANDED GROUP "A" PLASTICS AS ALLOWED IN AREAS WITH DECK HEIGHTS OF UNDER 40'-0". THE USE OF 22.4K ESFR SPRINKLERS WITH A MINUMUM END HEAD PRESSURE OF 40PSI IS USED AND CARRIED AT LEAST 15'-0" BEYOND THAT DECK HEIGHT, SEE MORE DETAILS PROVIDED IN THE GENERAL NOTES ON FP1

10'-0"		0"	DETAILS PROVIDE	ED IN THE G	ENERAL NO	BEYOND THAT DE DTES ON FP1		-0"	<u>[10'-0"]</u>	<u>10</u>	<u>'-0"</u>		<u>0'-0"</u>
	ຈັ ຟີ້ ສີ32LH382	288 [№]		R 		¢			∾(² 32LH382/288	3 1 1 			~ <mark>3</mark>
	212 10-0	- 	<u> </u>	10-0	~~~~~~~~~~~~~~~~~~~~~~~~~~~~~~~~~~~~~~~	10-0	10-0	2	° 0	10-0	10-0 10-0	10-0	10-0
<u>4</u> 10-0	38)-57 -6 -6 -6	ر اع الم بر 4 8-6	4 - 10-0			4 10-0	STIT .	4 -6 4	4 10-0	2 Th		4 6-6	↓ ↓ ↓ ↓ ↓ ↓ ↓ ↓ ↓ ↓ ↓ ↓ ↓ ↓
10-0	2 ¹²	€ 1-1 1-2		60VG8N12.5K	5 +	€) (≁ -1 1-1	0−0 ' 3−6 11−4 2 11−4	€ 1 1 1 1 1 1 1 1 1 1 1 1 1 1 1 1 1 1 1	€ 7 1 7 1 7
TOR YP.)	21 <u>2</u> -212 5-2 -2 -10	2 5-2 4-10		5-2 6	2 2	5-2 ⁶ 4-10	2 6 5-2 6 4-10			5-2 6 4-10	2 5-2 6-10	2 6-2 4-10	2 5-2 4-10
22.4K ESFR MAX DEFLECTOR E 18" BELOW DECKING (TYP.)	212 *	∰ ₽ 	DEFLEC	8-6	5	9-8	8-10-75	7) 	v 9-8	8 8 8 8 9 8	5- 2- 9€	9 ⁶
DISTANCE 18" B	0-0		STANCE	0 					2	0 -0			
				C	<mark>₹710</mark> ~ 5	= 	4 <mark>−</mark> −−−−−−−−−−			= 	~~~~~~[-~~	
		~~~~~~~~~~~~~~~~~~~~~~~~~~~~~~~~			N (711)	80 	8 8 8		œــــــــــــــــــــــــــــــــــــ	- ∞  ∞	8 8-8		~~~~~~~~~~~~~~~~~~~~~~~~~~~~~~~~~~~~~~
"	2 ¹²		_ <u>7</u> 121.1_	€ - <u>- </u> <u>-</u> - <u>-</u>	 121.1	10-0			) (1997) 1997) 1997) 19	₩ • <u>*</u> 8" • -2	 -0-0 -0-0 		(704) 121.1	7 121.1	60VG8N12.5	<u>(712</u> )- 121.1	5-3 FEAKED	<mark></mark>		)	₩ •	60VC8N12.5	 ®® 2 E	
	× 2 ¹² 5 3-3 6		, (705)	2	(709)	3-3 6 GRID PE	3-3 3-3 3-3 3-3 3-3 3-3 3-3 3-3 3-3 3-3	~~~~		2 2 2 2 2 2 2 2 2 2 2 2 2 2 2 2 2 2 2	<del>5.</del> ۳۵ ۲۳ ۱۳	2 2 2 3 3 3 3 3 3 3 3 3 3 3 3 3 3 3 3 3	بن ۲ ۲ ۲ ۲ ۲ ۲ ۲ ۲ ۲
	2 ¹ 2	<u>121.1</u>	7 121.1	7 9	<u>121.1</u>		10-0 4	~~~~~~~~~~~~~~~~~~~~~~~~~~~~~~~~~~~~~~~	0-0 0-0	2 -0- 0-01	-0-0 -0	10-0	10-0 10-0
	<b>*</b>					•		**	) (	**************************************		<b>()</b>	
DEFLECTOR NG (TYP.)	212 9-0	2 1-9 9-0	DEFLECTOR NG (TYP.)		2 2 2 2 2 2 2	0-6		2 1-9 2			2 9-0	2 9-0	2 9-0 9-0
ESFR MAX [ BELOW DECK		۳ ۳ ۷ ۳	ESFR MAX [ BELOW DECK		5	ອ ອ	8-3 8-3	~~~~~~~~~~~~~~~~~~~~~~~~~~~~~~~~~~~~~~~		وت - ۲ - 8		6 <b>9</b> 8-3 8-3	۳ ۳ ۳
22.4K ESFR MAX DEFLECTOR DISTANCE 18" BELOW DECKING (TYP.)	8-6 8-6	الله الله الله الله الله الله الله الله	16.8K ESFR MAX DEFLECTOR DISTANCE 14" BELOW DECKING (TYP.)	9 8 	2	9-8 	9 9 9 9 9 9 9 9	~~~~~	ALL MAINS © 24" FROM THE DECK (TYP.)	y 9-8	8-6 8-6	8 -6 8-6	8-2 8-2
	*	<b>()</b>	(		Ø	<b>)</b> 	\$ <b>0</b> 	<b>*</b>	ALL MAIN	¥0 	<b></b>	Ø)	• •
6 6 7−6	-2 -2 -2 -2 -2 -3 -2 -3 -3 -3 -3 -3 -3 -3 -3 -3 -3		$\begin{array}{c} \begin{array}{c} \hline \\ \\ \\ \\ \\ \\ \\ \end{array} \end{array} \xrightarrow{6} \begin{array}{c} \\ \\ \\ \\ \end{array} \xrightarrow{6} \begin{array}{c} \\ \end{array} \xrightarrow{6} \end{array} \xrightarrow{6} \begin{array}{c} \\ \end{array} \xrightarrow{6} \end{array} \xrightarrow{6} \begin{array}{c} \\ \end{array} \xrightarrow{6} \begin{array}{c} \\ \end{array} \xrightarrow{6} \begin{array}{c} \\ \end{array} \xrightarrow{6} \end{array} \xrightarrow{6} \begin{array}{c} \\ \end{array} \xrightarrow{6} \end{array} \xrightarrow{6} \begin{array}{c} \\ \end{array} \xrightarrow{6} \begin{array}{c} \\ \end{array} \xrightarrow{6} \end{array} \xrightarrow{6} \begin{array}{c} \\ \end{array} \xrightarrow{6} \begin{array}{c} \\ \end{array} \xrightarrow{6} \end{array} \xrightarrow{6} \begin{array}{c} \end{array} \xrightarrow{6} \end{array} \xrightarrow{6} \begin{array}{c} \\ \end{array} \xrightarrow{6} \end{array} \xrightarrow{6} \begin{array}{c} \end{array} \xrightarrow{6} \end{array} \xrightarrow{6} \begin{array}{c} \end{array} \xrightarrow{6} \end{array} \xrightarrow{6} \begin{array}{c} \end{array} \xrightarrow{6} \end{array} \xrightarrow{6} \end{array} \xrightarrow{6} \begin{array}{c} \end{array} \xrightarrow{6} \end{array}$	60VG8N12.5		C12 C12 C12 C12 C12 C12 C12 C12	2 and	(C13) 6 5-0 €		-2 2 2 2 2 2 2 2 2 2 2 2 2 2 2 2 2 2 2	C15) C15) 	212 9-0			0-6	۲	0-0 -6	<u>-</u>	*			2	 -0 -0	
	212 0-0-0-0-0-0-0-0-0-0-0-0-0-0-0-0-0-0-0-	0-6	۲ <mark>۱</mark> ۲ ۱۹		0- ² 2	¢ 	9-0 -0	2 0-6	۲ <mark>۲</mark>		0- <mark>0-</mark>	9-0 9-0	25'-4"
/					ZONE ZONE		<b></b>					<b></b>	<b>_</b>
					]				ALL MAINS © 24" FROM THE DECK (TYP.)	9 	[		
	∞ /3	₽ ₩ ₩			(\ ()	9-8 9-8	9-6 	• •	ALL MAINS	9- 9- ₩	 ₩	8°6	2-2" 8-6
a $b$ $b$ $c$	212 212 200 2	, , , , , , , , , , , , , , , , , , ,		212 202 7-3		C C C C C C C C C C C C C C C C C C C		6 0-0		2 - 1 - 3 99 - 2 - 3			
,			ی پ ۱۰۰۲ - ۲۰۰۲ - ۲۰۰۰ - ۲۰۰۰ - ۲۰۰۰ - ۲۰۰۰ - ۲۰۰۰ - ۲۰۰۰ - ۲۰۰۰ - ۲۰۰۰ - ۲۰۰۰ - ۲۰۰۰ - ۲۰۰۰ - ۲۰۰۰ - ۲۰۰۰ - ۲۰۰۰		1-3	دل م ت		1-3 2					
	21 ²			60VG8N12.5K	2	6-2	7-9	۲ ه ه	,		60VG8N12.5K	2 7-9	2 
	21 <u>2</u> 10-0		<u> </u>			0 	10-0			7 <mark>-0</mark> -0-	0 -0	-0 -0	10-0
	*		(		٢				)		<b>3</b> 0		
			- DECK HEIGHT OF	OVER 40'-	O"THE US	6.3.3.1 & 17.3.3.1 E OF 16.8K SPRIN D UNEXPANDED G	KLERS IS PRO	DHIBITED					

DECK HEIGHT OF OVER 40'-0" THE USE OF 16.8K SPRINKLERS IS PROHIBITED AS WELL AS THE STORAGE OF EXPOSED UNEXPANDED GROUP "A" PLASTICS AS ALLOWED IN AREAS WITH DECK HEIGHTS OF UNDER 40'-0". THE USE OF 22.4K ESFR SPRINKLERS WITH A MINUMUM END HEAD PRESSURE OF 40PSI IS USED AND CARRIED AT LEAST 15'-0" BEYOND THAT DECK HEIGHT, SEE MORE DETAILS PROVIDED IN THE GENERAL NOTES ON FP1

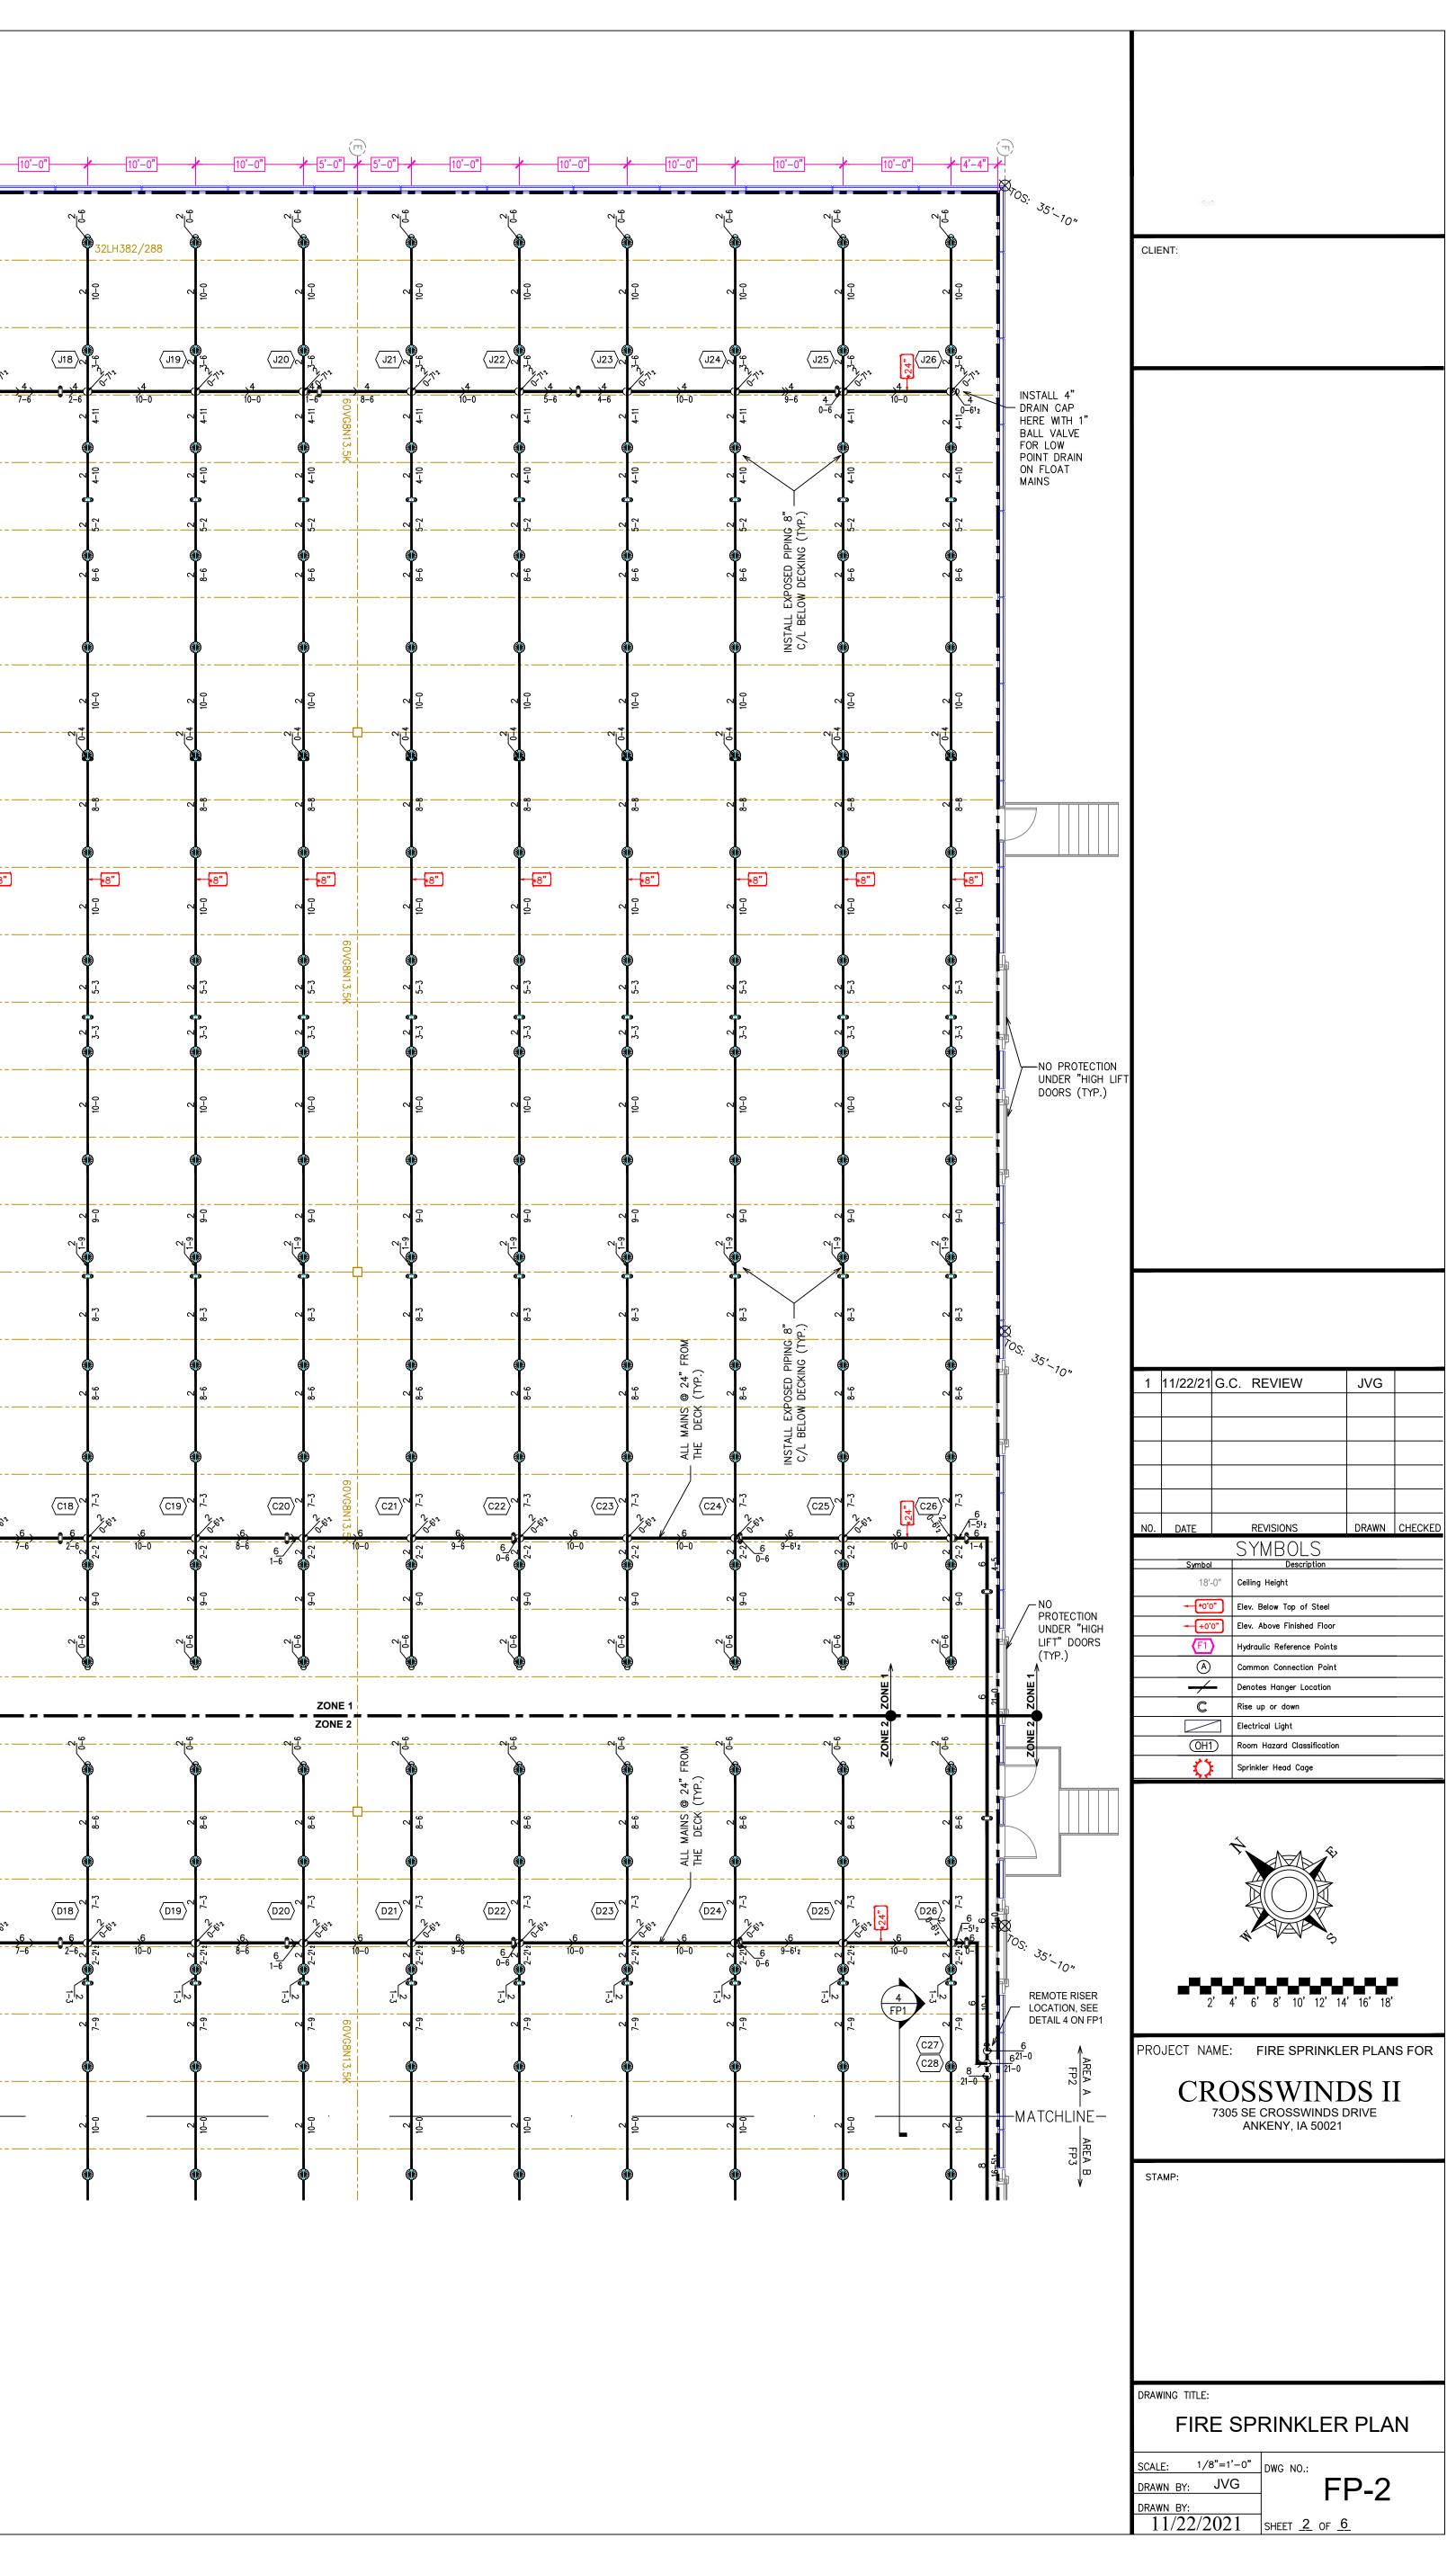

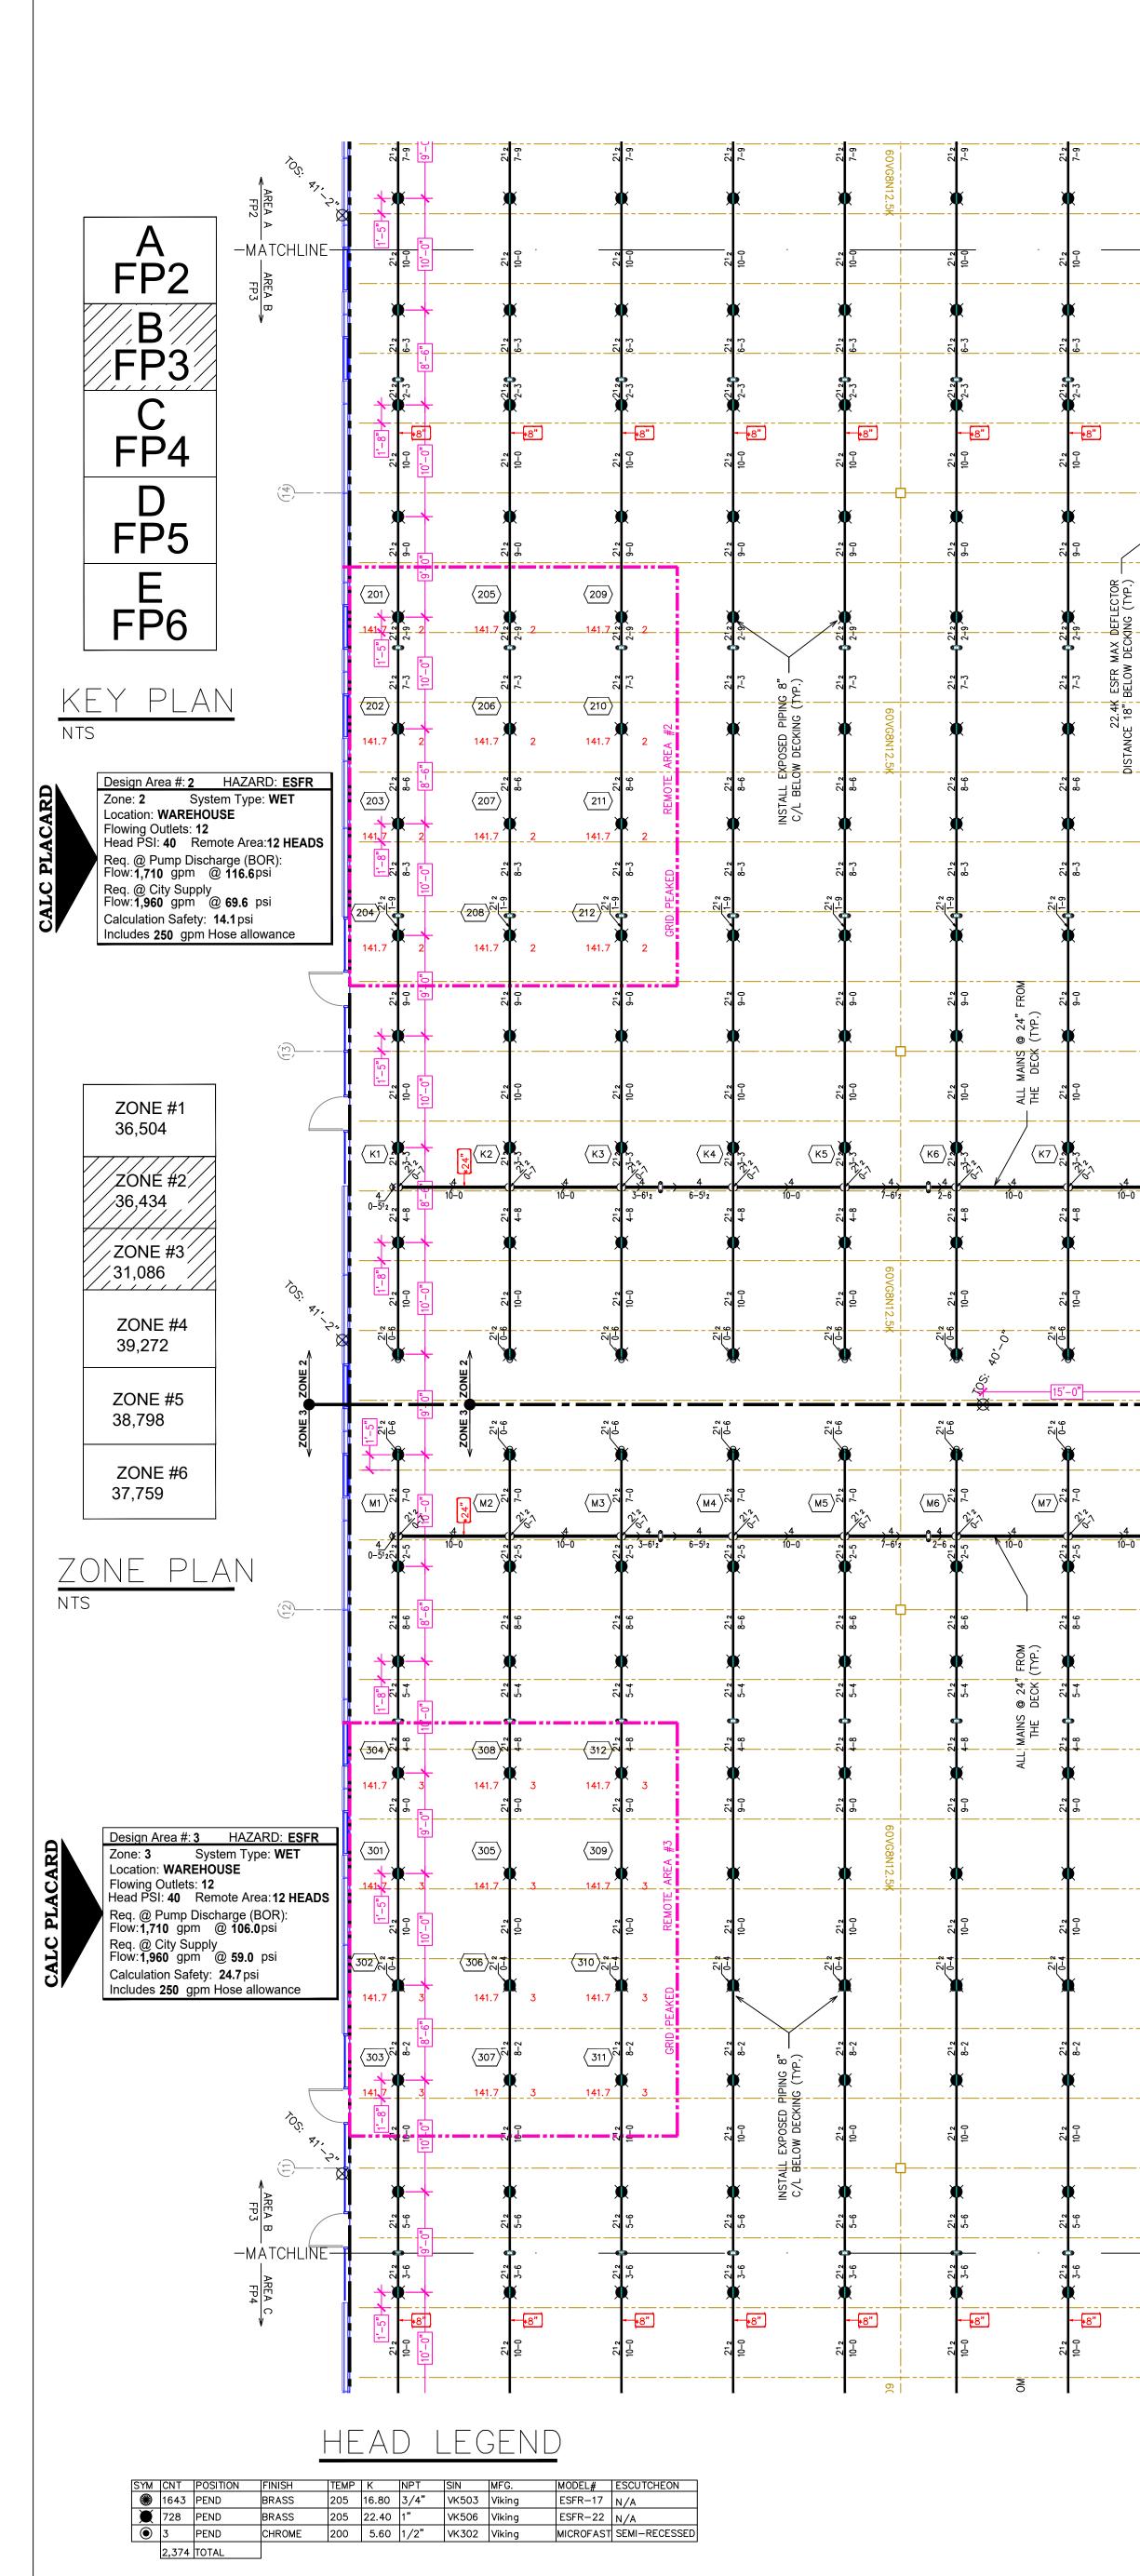


			DECK HEIGHT AS WELL AS ALLOWED IN A 22.4K ESFR S	OF OVER 40'- THE STORAGE ( REAS WITH DE PRINKLERS WIT RRIED AT LEAS	0" THE U OF EXPOS CK HEIGH TH A MINU ST 15'-0"	SE OF 16.8K SPRIN ED UNEXPANDED G TS OF UNDER 40'– MUM END HEAD PF BEYOND THAT DEC	IN AREAS WITH A IKLERS IS PROHIBITED ROUP "A" PLASTICS 0". THE USE OF RESSURE OF 40PSI IS CK HEIGHT, SEE MORI	AS															
5		2 7-9	2 c	6-2 6-2						60VG8N12.5K						6-2 6-2			02 €6 6			8	DETAIL 4 ON FP1
5 	2 ¹² 10-0 2-3 2-3 6-3	♣ 2 2-3 1-3	2			2 2 4 *8"					7							2 10-0 2 2 2 2 2 2 2 3 4 4 2 3 4 4 4 4 4 4 4 4 4 4 4 4 4	10-0 10-0	10-0 10-0 2 2 2 2 2 2 2 2 2 2 2 2 2	2 ²⁻³ 2 ²⁻³ 2 ²⁻³ 2 ²⁻³ 2 ²⁻³ 2 ²⁻³	10-0 10-0 10-0 10-3 10-3 NO PROTECTION UNDER "HIGH LIFT" DOORS (TYP.)
22.4K ESFR MAX DEFLECTOR DISTANCE 18" BELOW DECKING (TYP.)	8-3 8-3	2 8-5 8-5 2 8-6 2-9 2-9 2-9 2-9 2-9 2-9 2-9 2-9		60VG8N12.5K						6+7 p €-2 9-8 0 €-8	2 2 2 2 8 2 2 8 2 2 8 2 2 2 8 2 2 8 2 2 8 8 2 2 8 8 2 2 8 8 8 2 2 8 8 8 8 8 8 8 8 8 8 8 8 8 8 8 8 8 8 8 8			² 8-5 ² 8-6 ² 7-3 ² 2-9 ² 2 2 2 2 2 2 2 2 2 2 2 2 2 2 2 2 2 2		60VG8N13.5K			8-6 8-7-3 8-6 7-3 8-6 7-3 8-6 7-3 8-6 7-3 8-6 8-6 8-6 8-6 8-6 8-6 8-6 8-6 8-6 8-6	7-3 2 3 8" 7P.) 2	8-5 		24"
а (кв) 	$\begin{array}{c ccccccccccccccccccccccccccccccccccc$	9-0 9-0		× 0-6	2 9-0	; ~		4-8 24" FRON			2 7 7 7 7 7 7 7 7 7 7 7 7 7 7 7 7 7 7 7	j v	φ     φ     v 0- 6 0			<ul> <li>9-0</li> <li>0 -0</li> <li></li></ul>	$0^{-6}$	۲۵ - ² - ²		INSTALL 4" DRAIN CAP HERE WITH 1" BALL VALVE FOR LOW POINT DRAIN ON FLOAT MAINS
2 2 2 2 2 2 2 2 2 2 2 2 2 2 2 2 2 2 2			ے مربع 		ZONE 2 ZONE 3 CN ⁶⁻		2		ب ب ب ب ب ب ب ب ب ب ب ب ب ب ب ب ب ب ب			بے مربط مربط مربط مربط مربط مربط مربط مربط	ч Г. У «М 18) С И С М 18) С И С И С И С И С И С И С И С И С И С	ب ب ب ب ب ب ب ب ب ب ب ب ب ب ب ب ب ب ب	بے ا ا ا ا ا ا ا ا ا ا ا ا ا ا ا ا ا ا ا	ZONE 2 ZONE 2 ZONE 3	ب	Ч		2			NO PROTECTION UNDER "HIGH LIFT" DOORS
	$\begin{array}{c ccccccccccccccccccccccccccccccccccc$	9-0 4-8 5-4	* · · · · · · · · · · · · · · · · · · ·	9-0 	2 0-0 1-8 2 2 2 2 2 2 2 2 2 2	; ; ; ; ; ; ; ; ; ; ; ; ; ; ; ; ; ; ;		9-0 4-8 5-4 9-0 ALL MAINS @ 24 THE DECK	2 -0 -0 -1 -1 -1 -1 -1 -1 -1 -1 -1 -1	9-0 <b>1</b> 5-4	5 5 7 7 8	2000 € 2000 € 2000 € 2000 € 2000 € 2000 € 2000 € 2000 € 2000 € 2000 € 2000 € 2			9-0 				9-0 The second s		9-0 2 2 2 2 2 2 2 2 2		INSTALL 4" DRAIN CAP HERE WITH 1" BALL VALVE FOR LOW POINT DRAIN ON FLOAT MAINS
5	$\begin{array}{c ccccccccccccccccccccccccccccccccccc$	10-0 8-2 10-0			10-0 8-2 8-2 11-0 11-0				10-0 8-2 10-0 10-0 2 2 2 2 2 2 2 2 2 2 2 2 2 2 2 2 2 2		2 2 0-4 2 -4 2	10-0 8-2 8-2 0-0 0-0 0-0 0-0 0-0 0-0 0-0 0		$\begin{array}{c ccccccccccccccccccccccccccccccccccc$	10-0 8-2 2 2 2 2 2 2 2 2 2 2 2 2 2 2 2 2 2 2			2 2 10-0 10-0 2 10-0	10-0 38-2 10-0 2 2 2 2 2 2 2 2 2 2 2 2 2 2 2 2 2 2 2	10-0 L EXPOSED ELOW DECKI	00 0-4	10-0 8-2 1 10-0 8 8 8 8 8	8" BULK MAIN NO PROTECTION UNDER "HIGH LIFT" DOORS (TYP.)
5	$\begin{array}{c c} 2^{1}2 \\ 10-0 \\ 3-6 \\ 3-6 \\ 3-6 \\ 5-6 \\ 3-6 \\ 5-6 \\ 3-6 \\ 3-6 \\ 5-6 \\ 3-6 \\ 5-6 \\ 3-6 \\ 5-6 \\ 3-6 \\ 5-6 \\ 3-6 \\ 5-6 \\ 3-6 \\ 5-6 \\ 3-6 \\ 5-6 \\ 3-6 \\ 5-6 \\ 3-6 \\ 5-6 \\ 3-6 \\ 5-6 \\ 5-6 \\$	10-0	2 c		10-0 	(       	v ¹ 2. 2. 2. 2. 2. 2. 2. 2. 2. 2. 2. 2. 2.	NO											2 2 2 2 2 2 2 2 2 2 2 2 2 2 2 2 2 2 2	10-0 3-6 5-6 15-6 10-0 10-0 10-0 10-0 10-0 10-0 10-0 10	S OF TRICAL RAMED	8 3-6 3-6 3-6 3-6 3-6 3-6 3-6 3-6 3-6 3-6	MATCHLINE- PP3 B PAREA D PP3 AREA C PP4 C PAREA C PP4 C PP4 C PP4 C

PER NFPA 13 TABLES 14.4.1, 15.4.1, 16.3.3.1 & 17.3.3.1 IN AREAS WITH A DECK HEIGHT OF OVER 40'-0" THE USE OF 16.8K SPRINKLERS IS PROHIBITED AS WELL AS THE STORAGE OF EXPOSED UNEXPANDED GROUP "A" PLASTICS AS ALLOWED IN AREAS WITH DECK HEIGHTS OF UNDER 40'-0". THE USE OF 22.4K ESFR SPRINKLERS WITH A MINUMUM END HEAD PRESSURE OF 40PSI IS USED AND CARRIED AT LEAST 15'-0" BEYOND THAT DECK HEIGHT, SEE MORE DETAILS PROVIDED IN THE GENERAL NOTES ON FP1

V SCALE: 1/8" = 1'-0" $\mathbf{\lambda}$ 

🔊 FIRE SPRINKLER PLAN – AREA B

4 ON FP1								
٨								
FP2 I AREA B	CLIE	ENT:						
LINE-								
AREA FP3								
₩ V								
ECTION R "HIGH								
DOORS )								
MAIN								
4" AP TH 1"								
_VE RAIN								
Т								
)*								
	1	11/22/21	G.C.	. RI	EVIEW	1	JVG	
ECTION R "HIGH								
DOORS ) 4"	N0.	DATE					DRAWN	
		DATE			VISIONS VBO	LS	DRAWN	
-v∟ ≀AIN T		18'-	-0" (		Height			
					elow Top ( bove Finisl			
		(F1 (A)	· · · · ·		ic Referen n Connect	ce Points tion Point		
		C			s Hanger   o or down	Location		
		(OH1			al Light Hazard Clo	ussification		
		Q	5	Sprinkle	er Head Co	age		
			Ŷ			^F		
MAIN				A				
				W		×,		
ECTION R "HIGH		2	2' 4'	<b>6</b> '	8'10	)' 12' 14	' 16' 18'	
DOORS )	PRC	JECT NA	ME:	F	IRE SF	PRINKLE	ER PLAN	IS FOR
		CR	RO	S	SW	INI	DS I	T
				SE (	ROSS	WINDS E IA 50021		_
AREA FP3	57	AMP:						
B	51/	AMP:						
LINE-								
AREA C								
)*								
	DRAV	WING TITLE:						
		FIR	ES	SPF	RINK	KLER	PLA	N
	SCAL		3"=1'-		DWG NC			
	DRAV	<u>WN BY:</u> WN BY: 1/22/2			0.15		P-3	
		1/22/2	υZΙ	-	SHFEL -	<u>3</u> of <u>6</u>	<u> </u>	

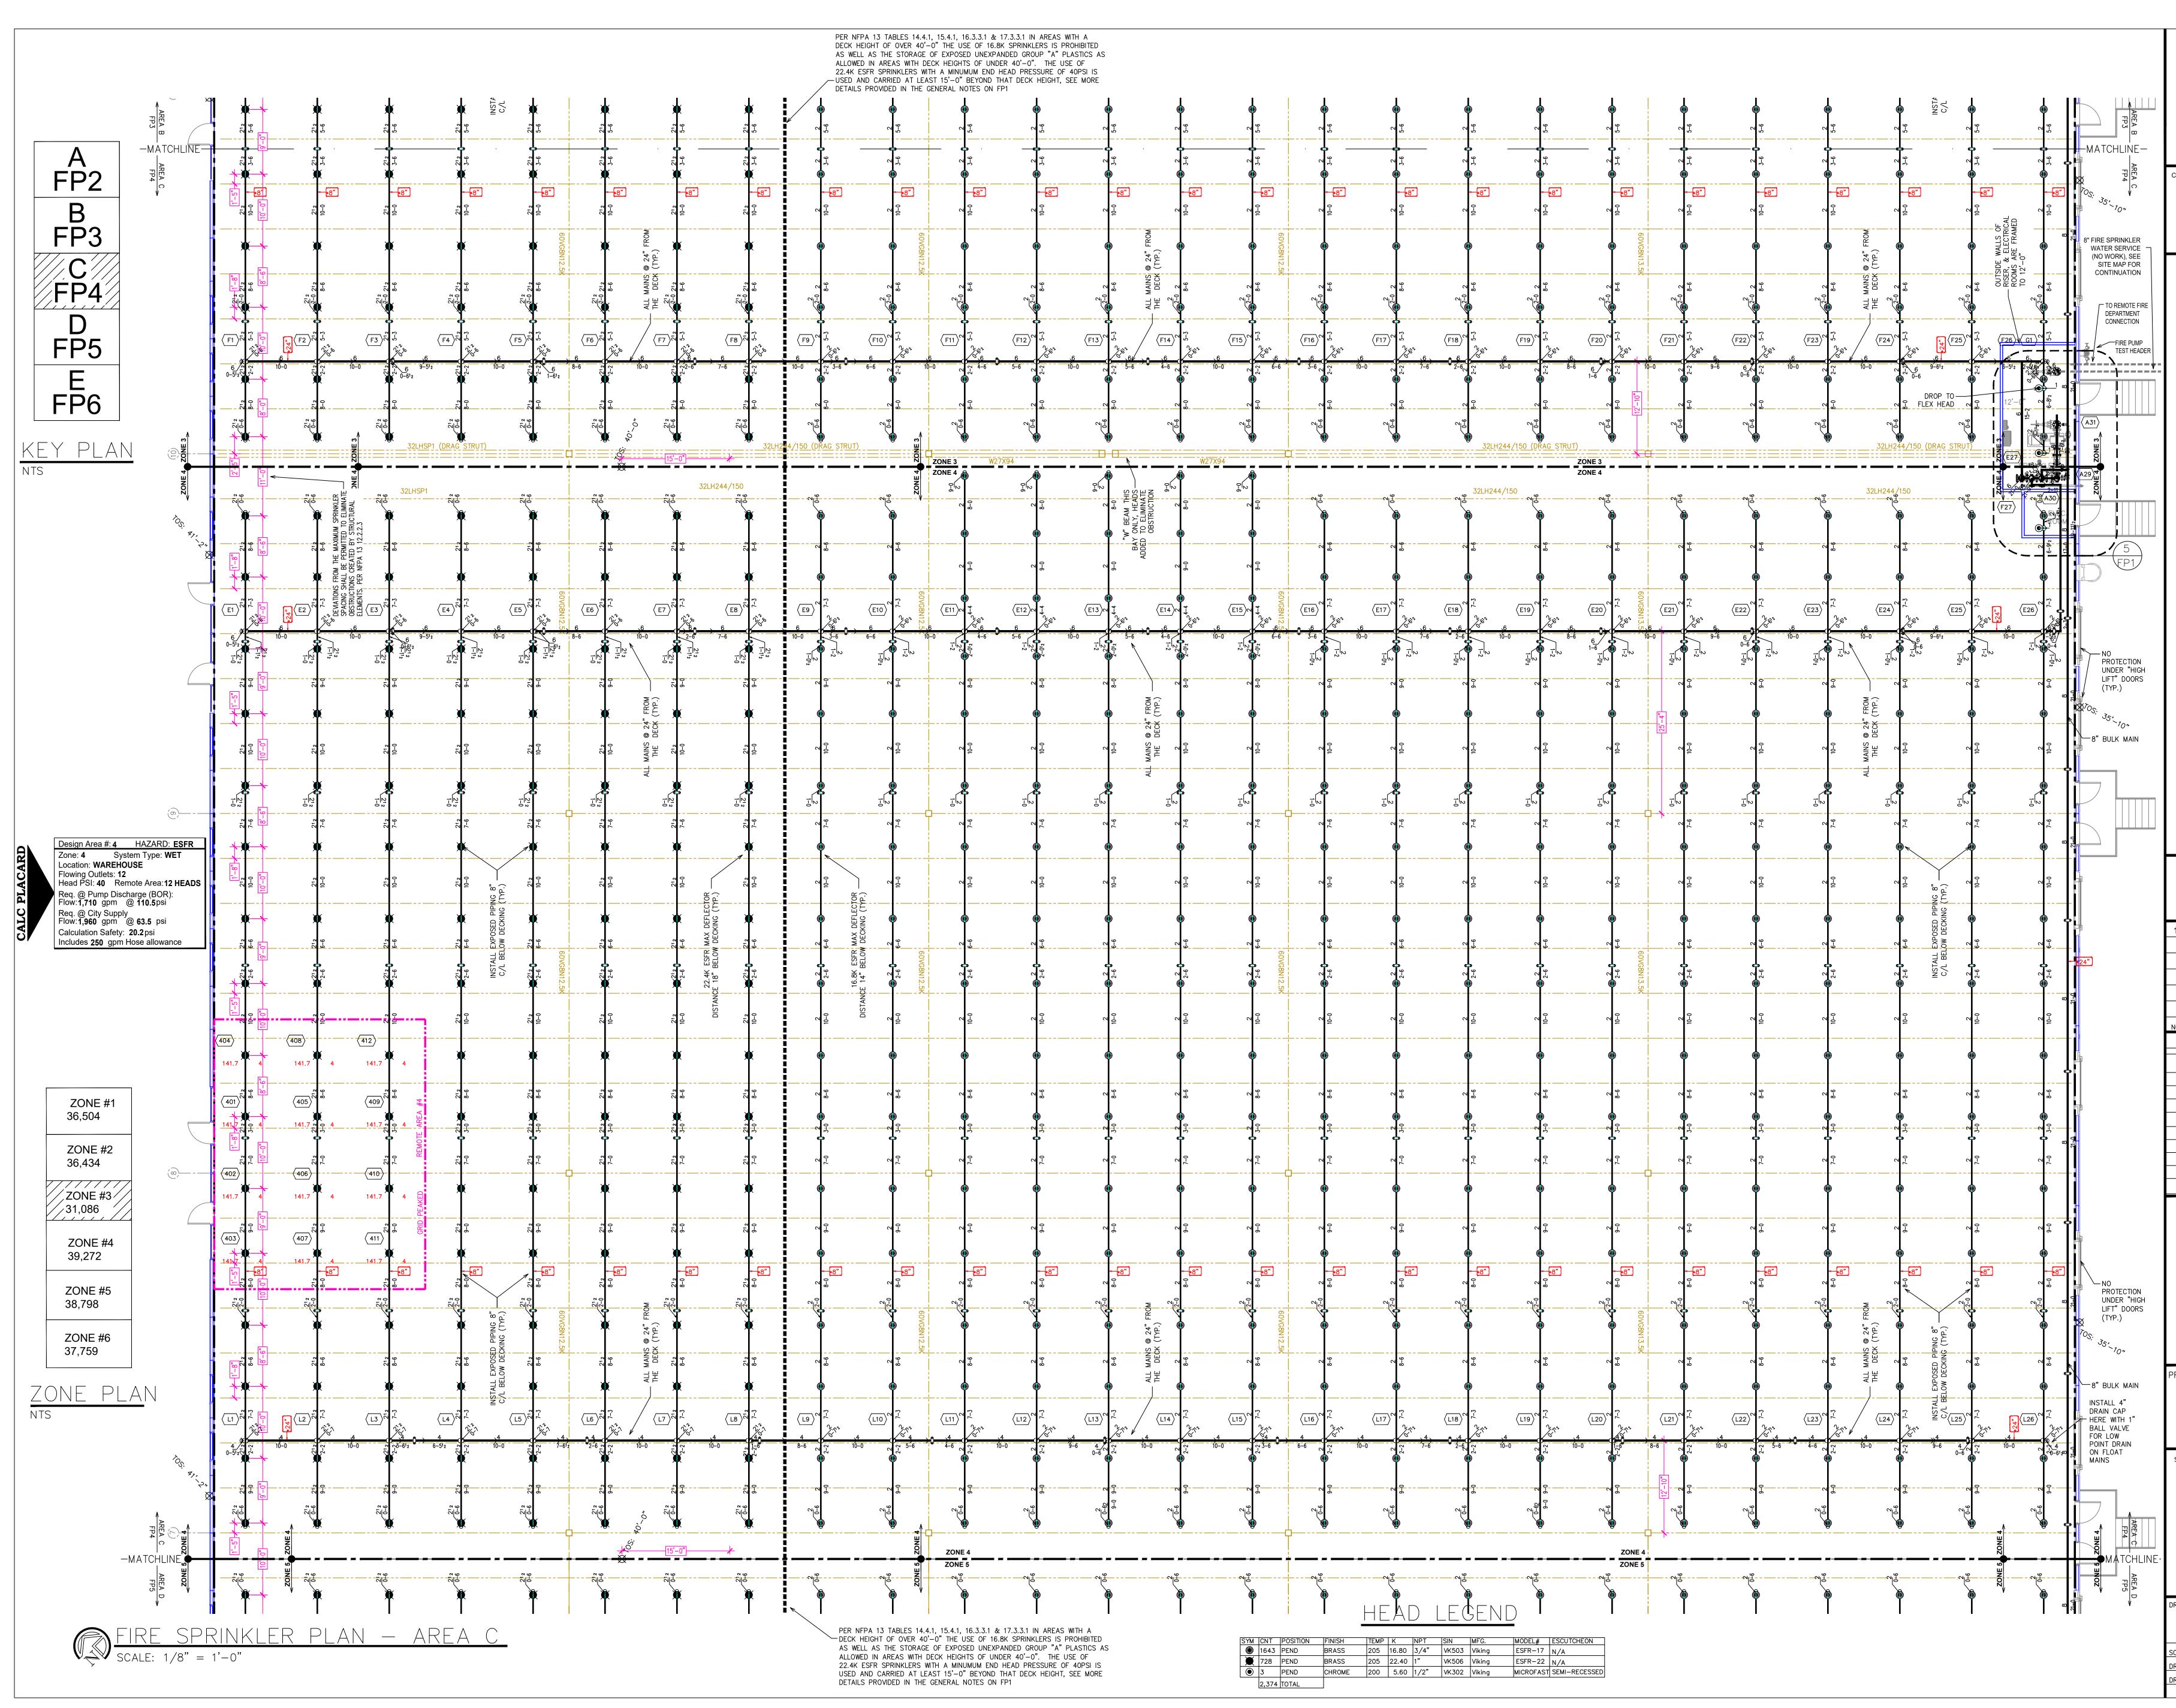

						]
	CLIE	ENT:				
r = = =						
-						
	1	11/22/21	G.(	C. REVIEW	JVG	
	N0.	DATE		REVISIONS	DRAWN	CHECKED
		Symbol		SYMBOLS Description		
		18'- 	_	Ceiling Height Elev. Below Top of Stee	<u>.</u>	
		+	0"	Elev. Above Finished Flo	or	
			1	Hydraulic Reference Poir Common Connection Po	int	
		C	-	Denotes Hanger Locatio Rise up or down	n	
		(OH1	] D	Electrical Light Room Hazard Classificat	tion	
		¢		Sprinkler Head Cage		
			,	A A A	\$>	
					\$	
		_				_
		2 2	,	4'6'8'10'12'	14' 16' 18'	
	PRO	JECT NA	ME	FIRE SPRIN	KLER PLAN	IS FOR
				DSSWIN		
				5 SE CROSSWINE ANKENY, IA 500	DS DRIVE	L
	STA	MP:				
٦						
∎ E-						
	DRAW	ING TITLE:				N I
				SPRINKLE	ER PLA	IN
		<u>E:</u> 1/8 /NBY:			FP-4	
_	DRAW	/n by: 1/22/2				
	_					