


FIRE PROTECTION PLAN	
1	REVISIONS
Project No.	473996
Drawn By	DWG
Date	9/20/2025
DWG Type	SUBMITTAL DWG
Printed No.	

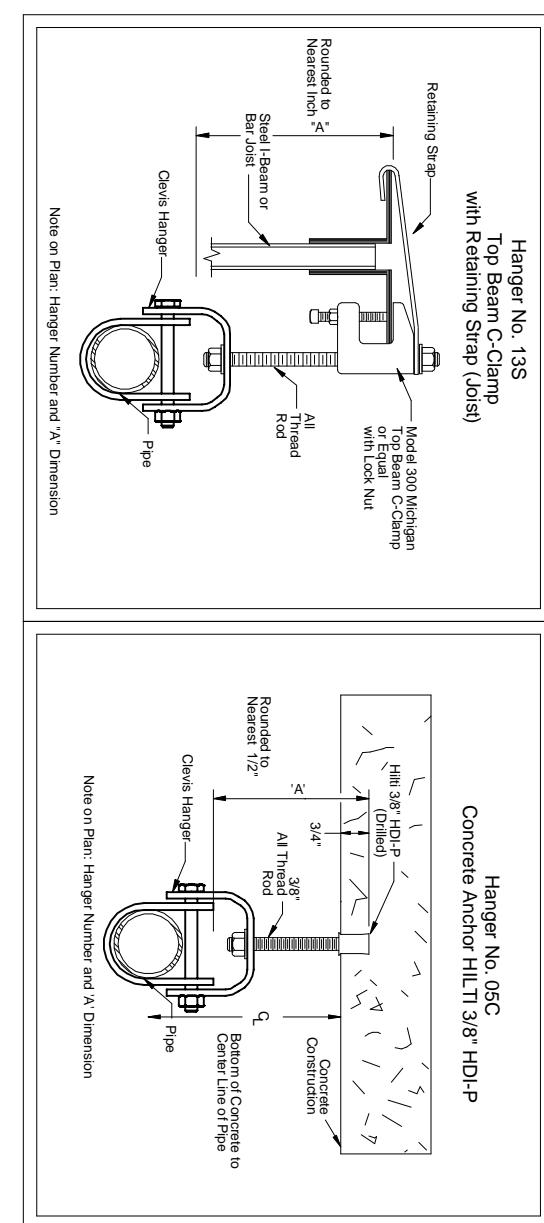


### NFPA 13 HANGER SPACING

SYM	COT	POSITION	FINISH	TEMP	K	NPFT	SIN	MFG	MODEL#	ESCAPEHEON	
										FIRE&G	SERVICES
25	PENDENT	CHROME	200	5-60	122°	RA444	RELUBLE	FIRE&G	SERVICES		


MAXIMUM DISTANCE BETWEEN HANGERS (FT-IN)

NOMINAL PIPE SIZE (IN.)	NOMINAL PIPE SIZE (IN.)								
	1"	1 1/4"	1 1/2"	2"	2 1/2"	3"	4"	6"	8"
SCHEDULE 40 STEEL PIPE	12-0	12-0	12-0	15-0	15-0	15-0	15-0	15-0	15-0

### SPRINKLER HEAD LEGEND

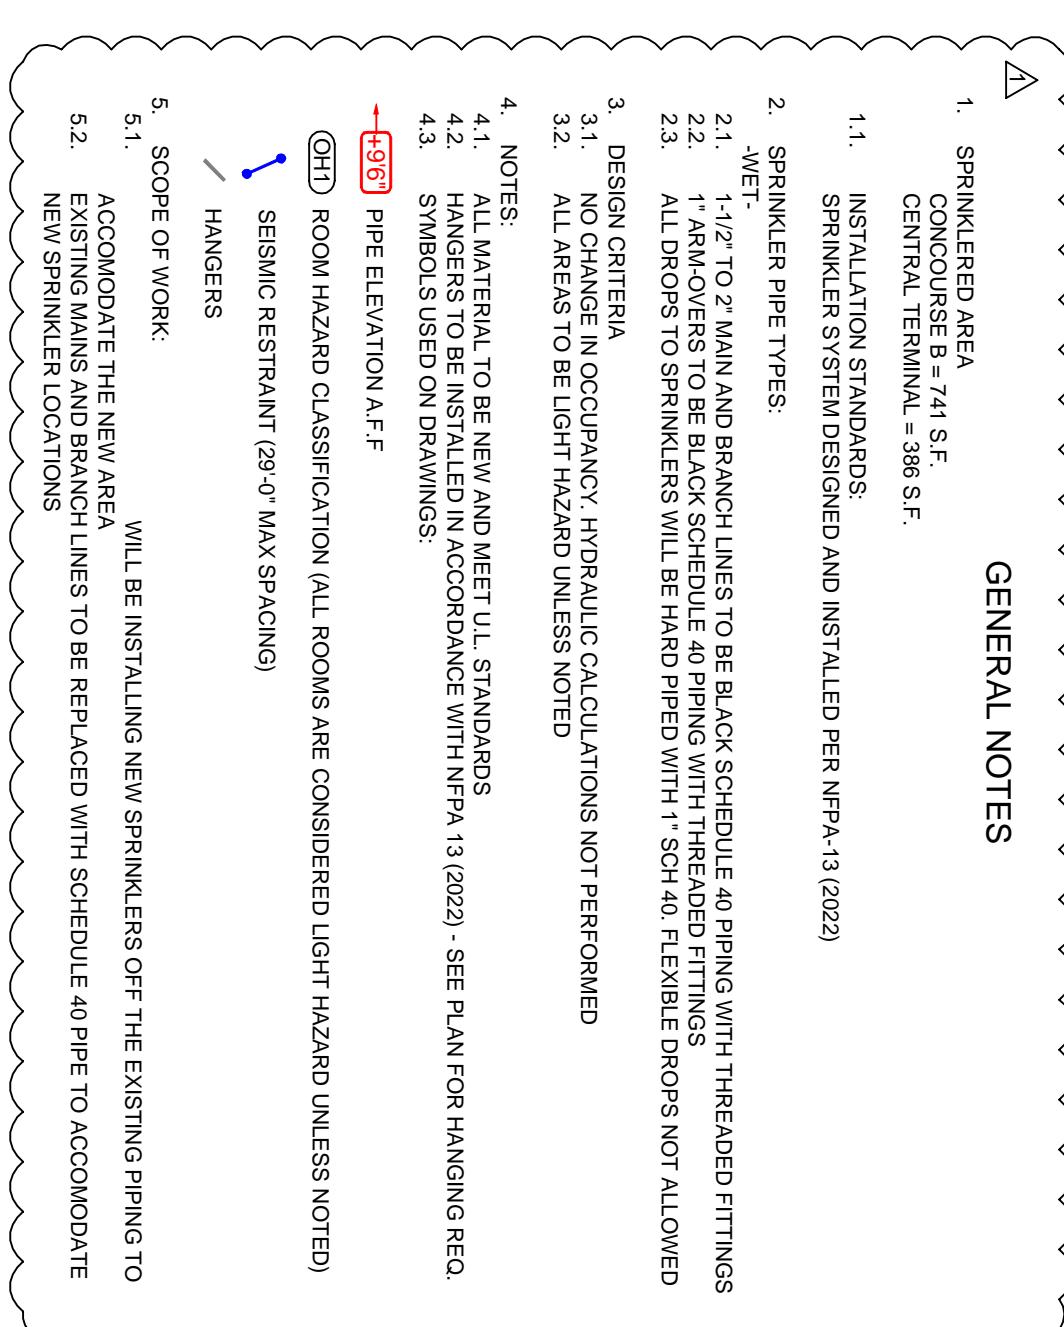

### SITE PLAN

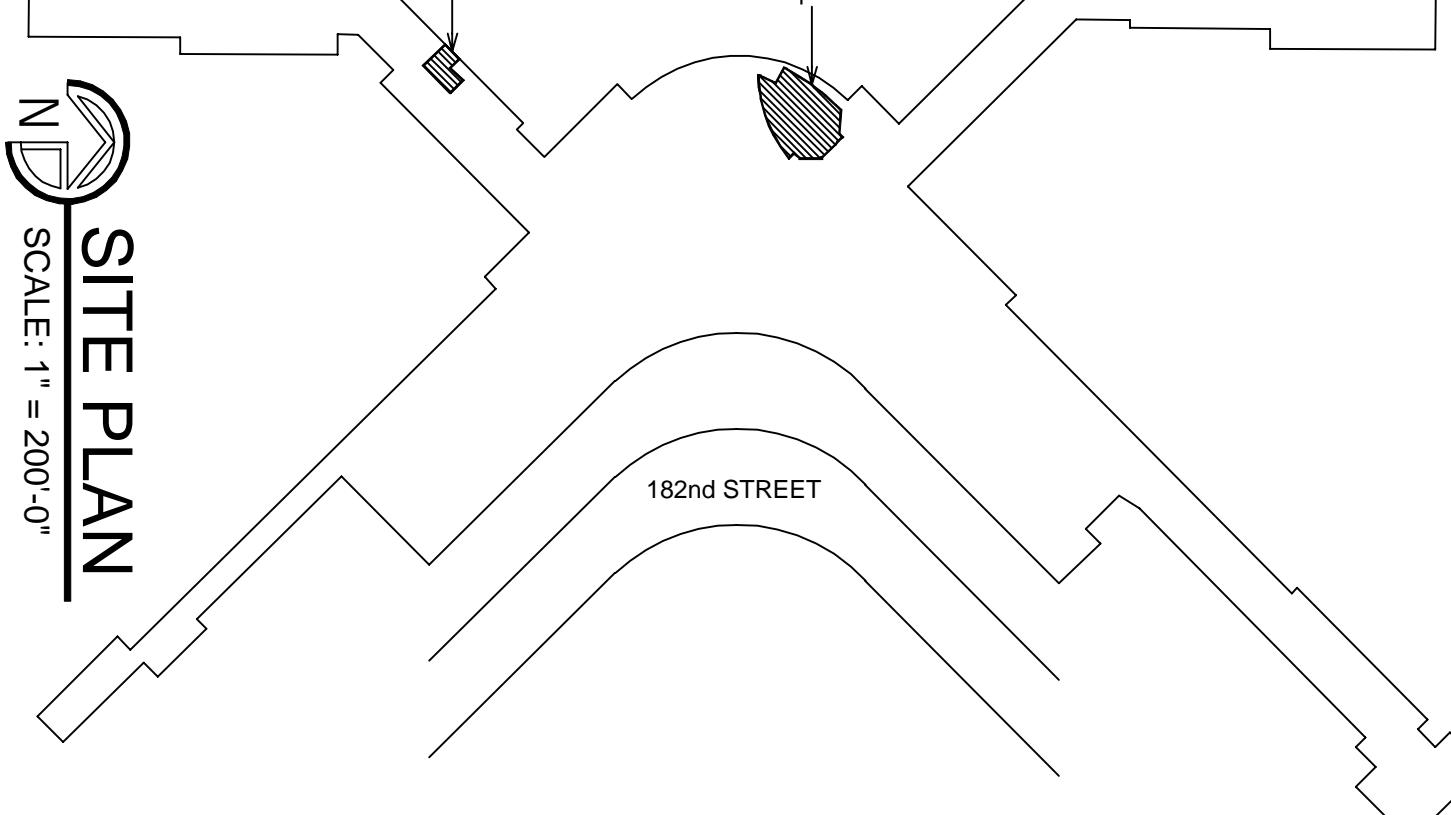

### AIRPORT FOOD & BEVERAGE

17801 INTERNATIONAL BLVD | SEATAC, WA