



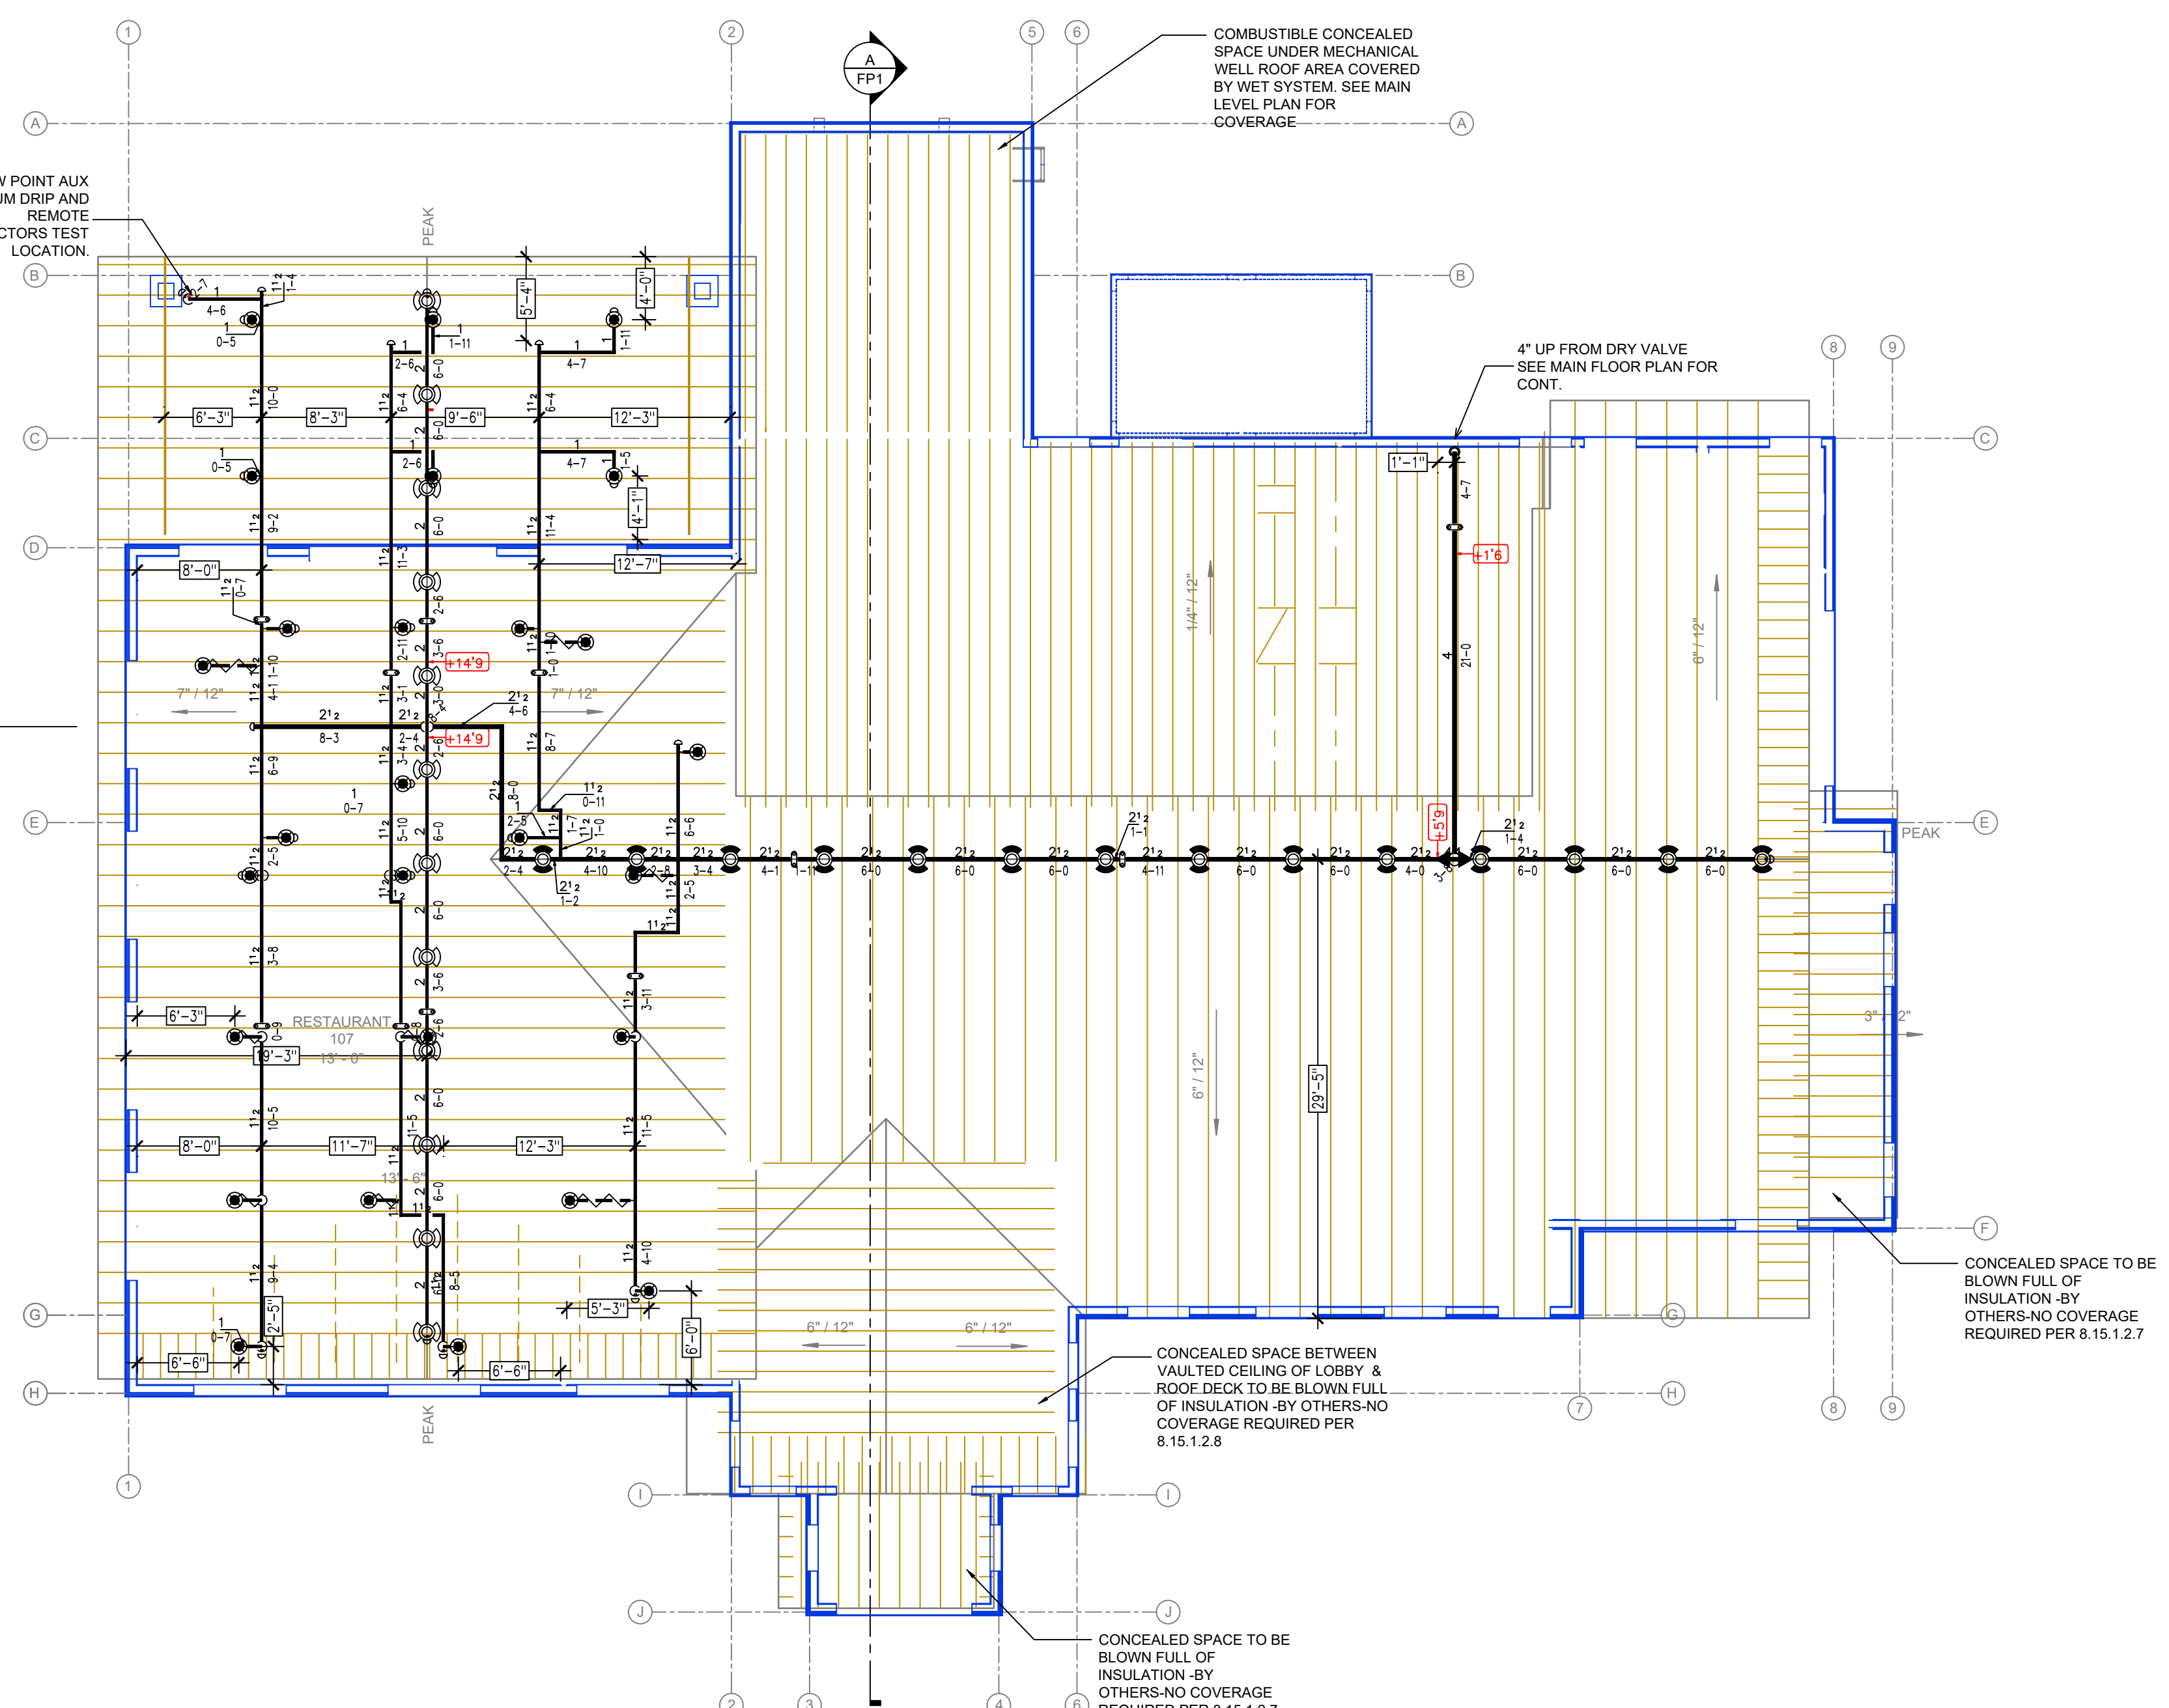


 **ATTIC LEVEL FIRE PROTECTION PLAN**
SCALE: 1/8" = 1'-0"

SPRINKLER HEAD LEGEND


SYM	CNT	POSITION	FINISH	TEMP	K	NPT	SIN	RTGS	MODEL#	ES/OUT/CHRN	SPACING
42	PENDING	CHROME	200	5.60	1/2"	RA1414	RELIABLE	FFR556	SEMI RECESSED	225SF LIGHT / 1305F OH	
5	PENDING	CHROME	200	5.60	1/2"	RA1425	RELIABLE	FFR556	NONE	225SF LIGHT / 1305F OH	
7	SPRG	BRASS	212	5.60	1/2"	RA4454	RELIABLE	CC-S	STANDARD	226SF (16"X16" MAX)	
5	SEWALL	CHROME	200	5.60	1/2"	RA1435	RELIABLE	FFR556	SEMI RECESSED	226SF LIGHT / 1305F OH	
21	PENDING	CHROME	200	5.60	1"	R5714	RELIABLE	FFR3	STANDARD	106SF LIGHT / 1055F OH	
5	PENDING	CHROME	200	5.60	1/2"	RA1425	RELIABLE	FFR556	SEMI RECESSED	245F (19"X16" MAX)	
12	SPRG	BRASS	200	5.60	1/2"	RA5694	RELIABLE	DD56-27	NONE	6"40"	
4	SPRG	BRASS	200	5.60	1/2"	RA1425	RELIAB	FFR556	NONE	225SF LIGHT / 1305F OH	
2	SEWALL	CHROME	200	5.60	1"	R5734	RELIAB	FFR3	STANDARD	105SF LIGHT / 1055F OH	
12	SPRG	UPRIGHT	BRASS	200	8.00	3/4"	RA0692	RELIABLE	DD30-27	NONE	6"40"

PIPE LEGEND

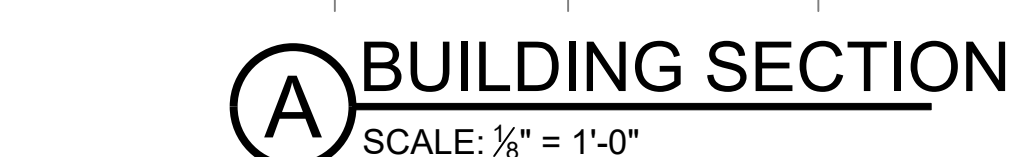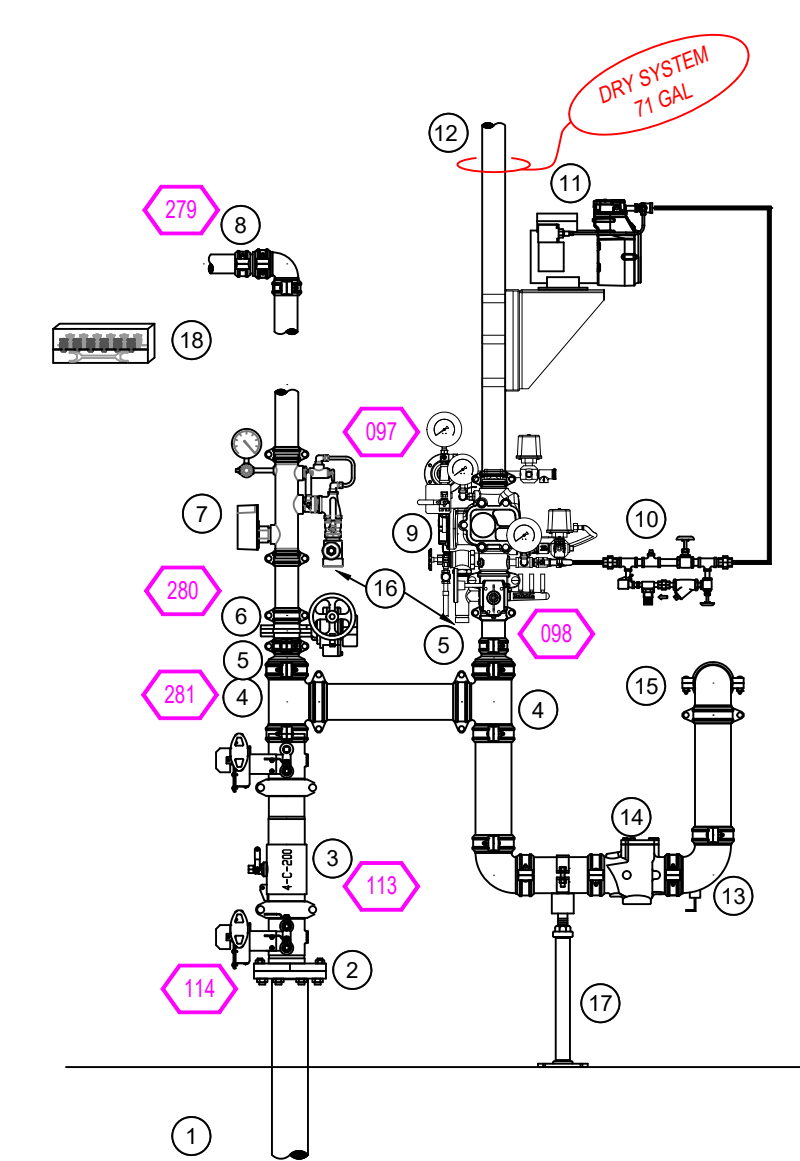

1 RISER DETAIL


NFPA 13 STEEL PIPE HANGER SPACING (EXCEPT LIGHT WALL THIRD PIPING)	
NOMINAL SIZE inches	MAX SPACING feet
1"	12'-0"
1-1/4"	12'-0"
1-1/2"	15'-0"
2"	15'-0"
2-1/2"	15'-0"
3"	15'-0"
4" & LARGER	15'-0"

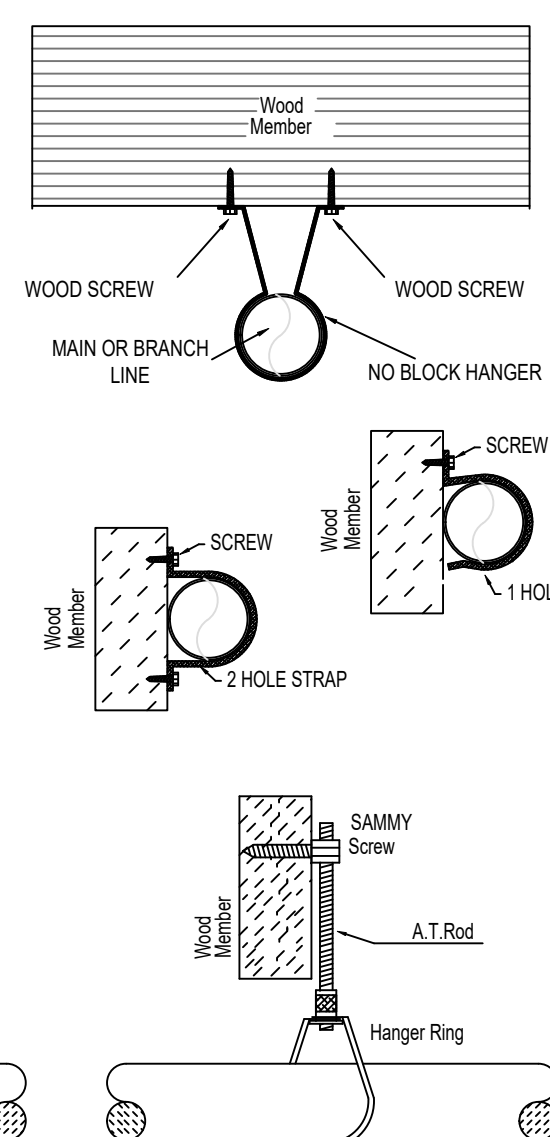

HANGER DETAILS

GENERAL NOTES

- INTERNATIONAL BUILDING CODE (2021)
1. OCCUPANCY: TYPE A-3, B
2. TYPE OF CONSTRUCTION: V-B
3. SPRINKLERED AREAS (APPROXIMATE - SEE ARCHITECTURAL PLANS FOR ACTUAL)
- MAIN LEVEL = 7,320 S.F.
- ATTIC = 5,577 S.F.
4. INSTALLATION STANDARDS:
- SPRINKLER SYSTEM DESIGNED AND INSTALLED PER NFPA-13(2016)
2. SPRINKLER PIPE TYPES:
- WET-
1. "1" BRANCH LINES TO BE BLK SCHEDULE 40 PIPING WITH THREADED FITTINGS
2. 1/2" THROUGH 4" MAIN & BRANCH LINES TO BE BLK SCHEDULE 40 PIPING WITH GROOVED FITTINGS
3. MAINS & BRANCH LINES TO BE ROLL-GROOVED BLK SCHEDULE 40 PIPING
- DRY-
1. "1" BRANCH LINES TO BE THREADED BLK SCHEDULE 40 WITH THREADED FITTINGS
2. 1/2" THROUGH 4" MAIN & BRANCH LINES TO BE GROOVED BLK SCHEDULE 10 WITH GROOVED FITTINGS
3. MAINS & BRANCH LINES TO BE ROLL-GROOVED BLK SCHEDULE 10 PIPING
3. DESIGN CRITERIA
1. LOCATIONS ARE DESIGNATED TO DELIVER 8.0 GPM/S.F. OVER THE MOST DEMANDING 1500 S.F.
2. ORDINARY HAZARD GROUP 1 AREAS DESIGNATED TO DELIVER 8.0 GPM/S.F. OVER THE MOST DEMANDING 1500 S.F.
3. REMOTE AREA REDUCTIONS HAVE BEEN TAKEN WHERE APPLICABLE PER NFPA 13 SEC. 11.2.2.3
4. NOTES:
1. ALL MATERIAL TO BE NEW AND MEET U.L. STANDARDS
2. HANGERS TO BE INSTALLED IN ACCORDANCE WITH NFPA 13 (2016) - **SEE PLAN FOR HANGING REQUIREMENTS**
3. DRY SYSTEM PIPE SLOPE INSTALLATION
- SPRINKLER MAINS TO BE 1/2" PER 10 FEET
- SPRINKLER BRANCH LINES TO BE 1/4" PER 10 FEET
4. DRY SYSTEM CAPACITY
- 4.4.1. 71 GAL
5. SYMBOLS USED ON DRAWINGS:
-  PIPE ELEVATION A.F.F
-  ROOM HAZARD CLASSIFICATION (ALL ROOMS ARE CONSIDERED LIGHT HAZARD UNLESS NOTED)
-  HYDRAULIC CALCULATION JUNCTION POINT
-  CEILING HEIGHT
6. SCOPE OF WORK:
- 6.1. INSTALL A COMPLETE WET SYSTEM TO PROTECT THE FINISHED MAIN LEVEL AREAS WHERE WARM SPACE ABOVE THE FINISHED CEILING IS AVAILABLE. INSTALL A COMPLETE DRY SYSTEM TO PROTECT THE ATTIC AND ANY MAIN LEVEL SPACES THAT DO NOT HAVE A WARM SPACE FOR THE SPRINKLER PIPE TO BE ROUTED.
- 6.2. ALL PORTION OF THE BUILDING TO BE INSTALLED AND COVERED IN ACCORDANCE WITH THE LOCAL AUTHORITY HAVING JURISDICTION AND PER NFPA 13 (2016)

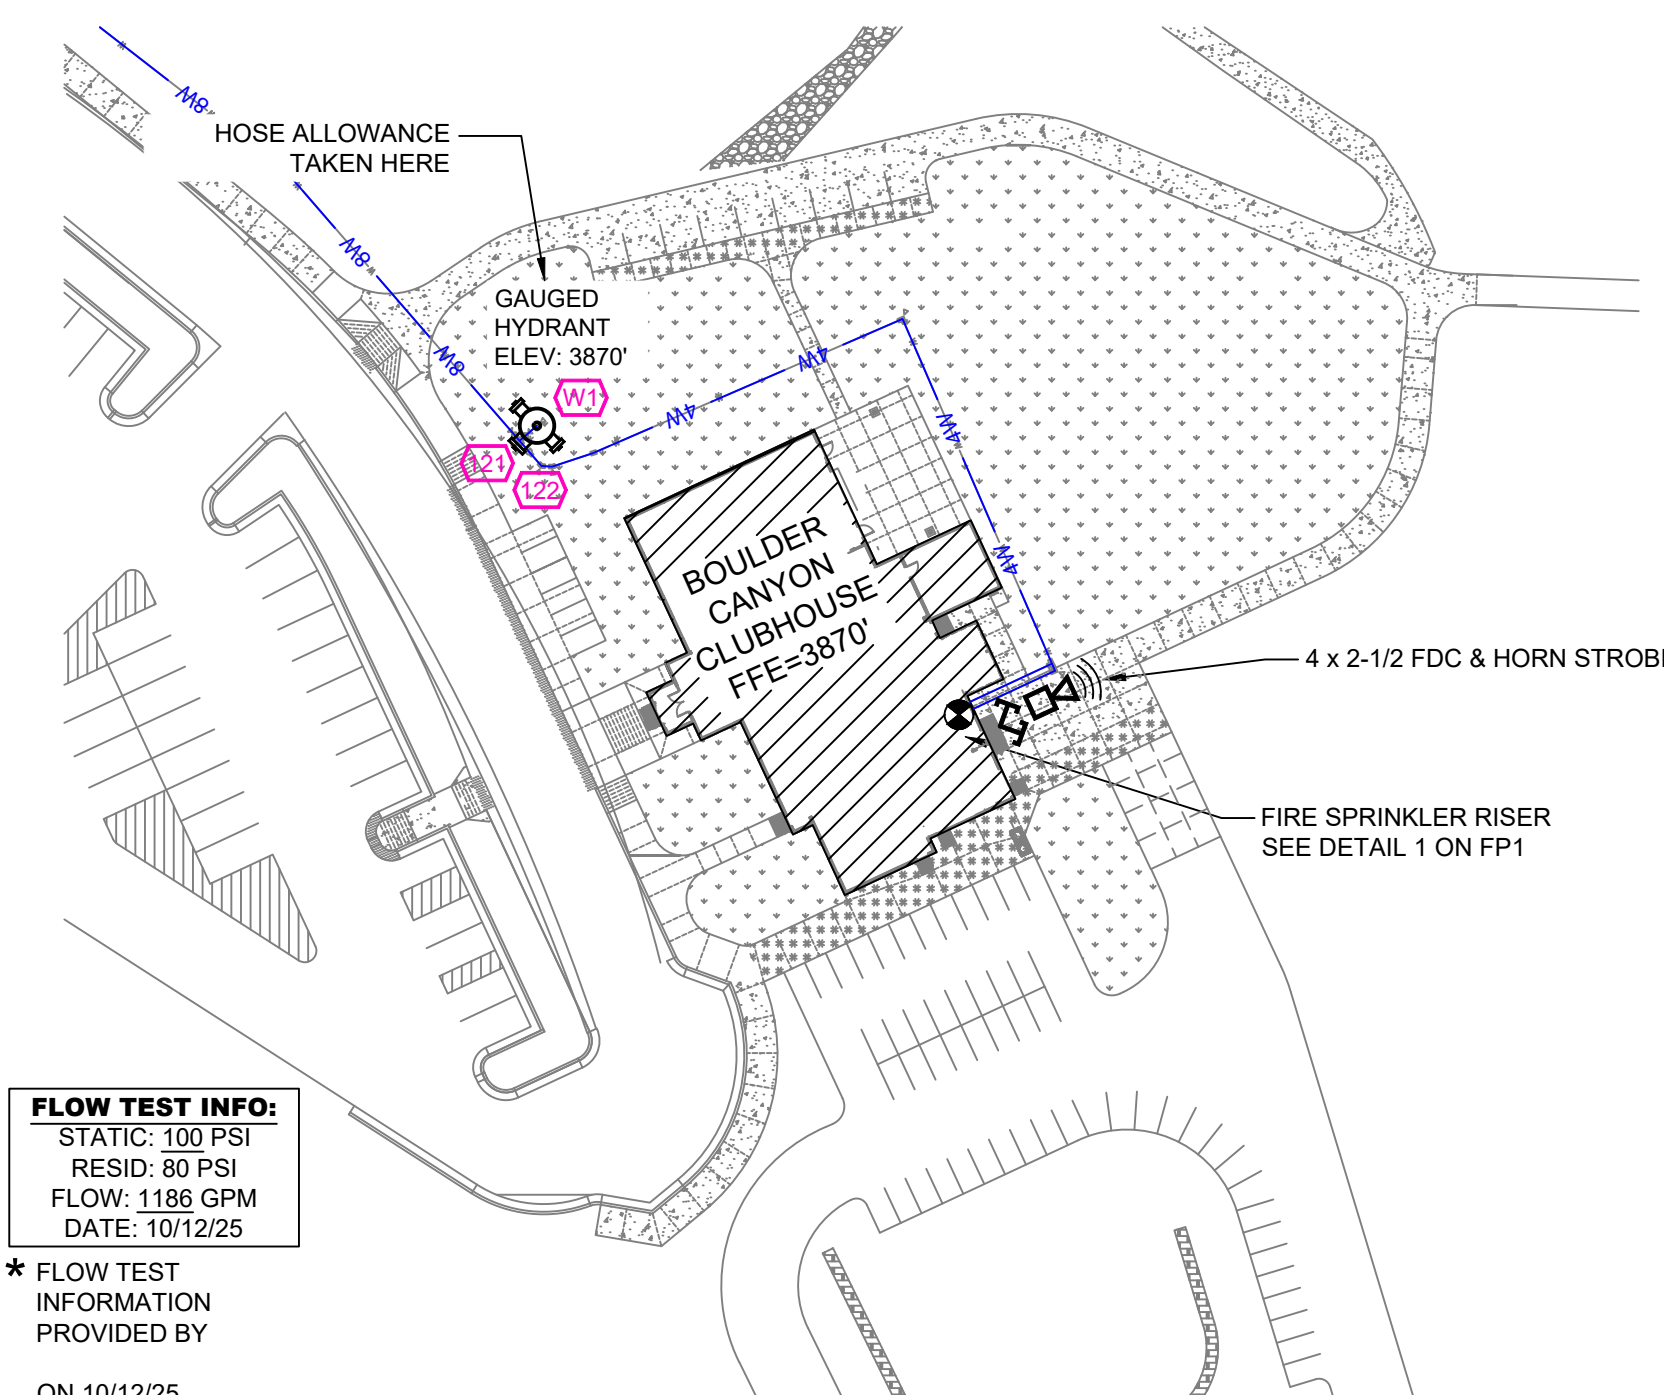

 **SITE PLAN**
SCALE: 1" = 50'-0"