


- | | | | | |
|-----|----------|----------------------|-------|---------|
| | | | | |
| | | | | |
| 3 | 10/23/25 | PLAN REVIEW COMMENTS | BCJ | JV |
| 2 | 10/1/25 | PLAN REVIEW COMMENTS | BCJ | JV |
| 1 | 9/12/25 | PLAN REVIEW COMMENTS | BCJ | JV |
| NO. | DATE | REVISIONS | DRAWN | CHECKED |

GENERAL CONTRACTOR:	AUTHORITY HAVING JURISDICTION:
	MAMMOTH LAKES FIRE DEPARTMENT
ADDRESS:	ADDRESS: 3150 MAIN ST.
CITY:	CITY: MAMMOTH LAKES, CA 93546
PHONE:	PHONE: 760-934-2300
CONTACT:	CONTACT:
ARCHITECT:	FIELD INSPECTIONS:
	1.
ADDRESS:	2.
CITY:	3.
PHONE:	4.




HANGER DETAILS

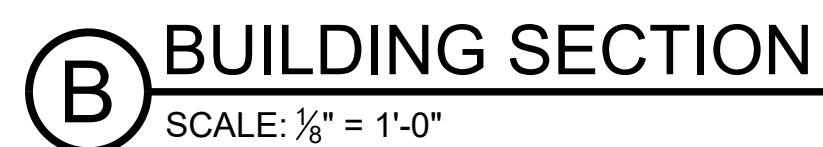

99 TOTAL NEW SPRINKLERS ON THIS JOB

FIRE SPRINKLER SYMBOL:

⊗	AUTOMATIC SPRINKLER RISER	+13" ELEV. BELOW DECK OR TOS
⊕	EARTHQUAKE BRACING	+12"-9" ELEV. ABOVE FINISHED FLOOR
⊕	2-WAY & 4-WAY	— CHANGE ELEVATION UP
⊕	PIPE HANGER & TYPE DESIGNATION	— CHANGE ELEVATION DN
○	HYDRAULIC REF PT	— INSPECTORS TEST
○	GRVD OR THRD CAP	— AUX DRAIN
⊕	GRVD COUPLING	△ REVISION NOTATION
⊕	TYPICAL POINT OF CONNECTION (POC)	⊕ LOCAL ALARM

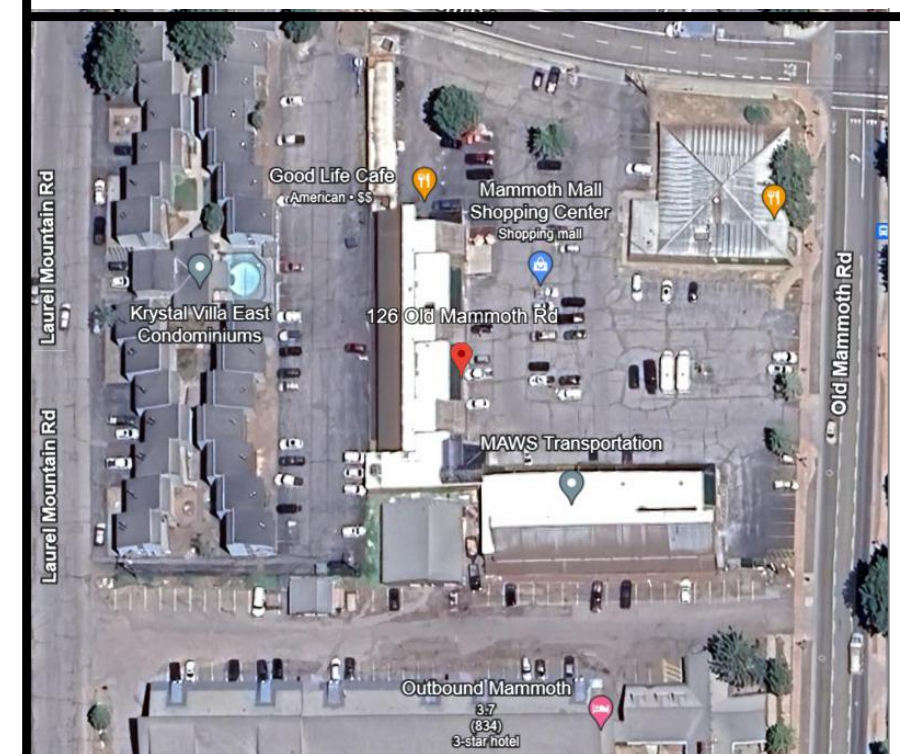

PROJECT NAME: FIRE SPRINKLER PLANS FOR

FIFTYFIFTY BREWING CO.


126 OLD MAMMOTH ROAD,
MAMMOTH LAKES, CA 93546

STAMP:


DRAWING TITLE:

FIRE SPRINKLER PLAN


SCALE: 1/8"=1'-0"	JOB NO.: 10/23/2025
DRAWN BY:	DWG NO:
BORN ON DATE: 10/23/2025	FP-1
FILE F: 10/23/2025	SHEET 1 OF 2

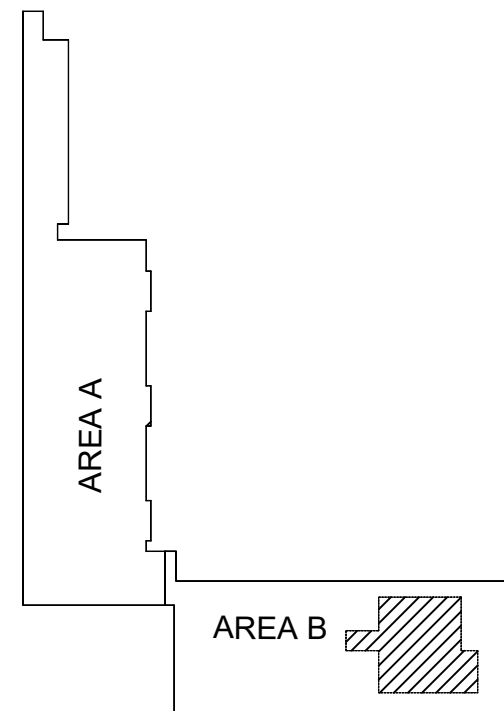

KEY PLAN

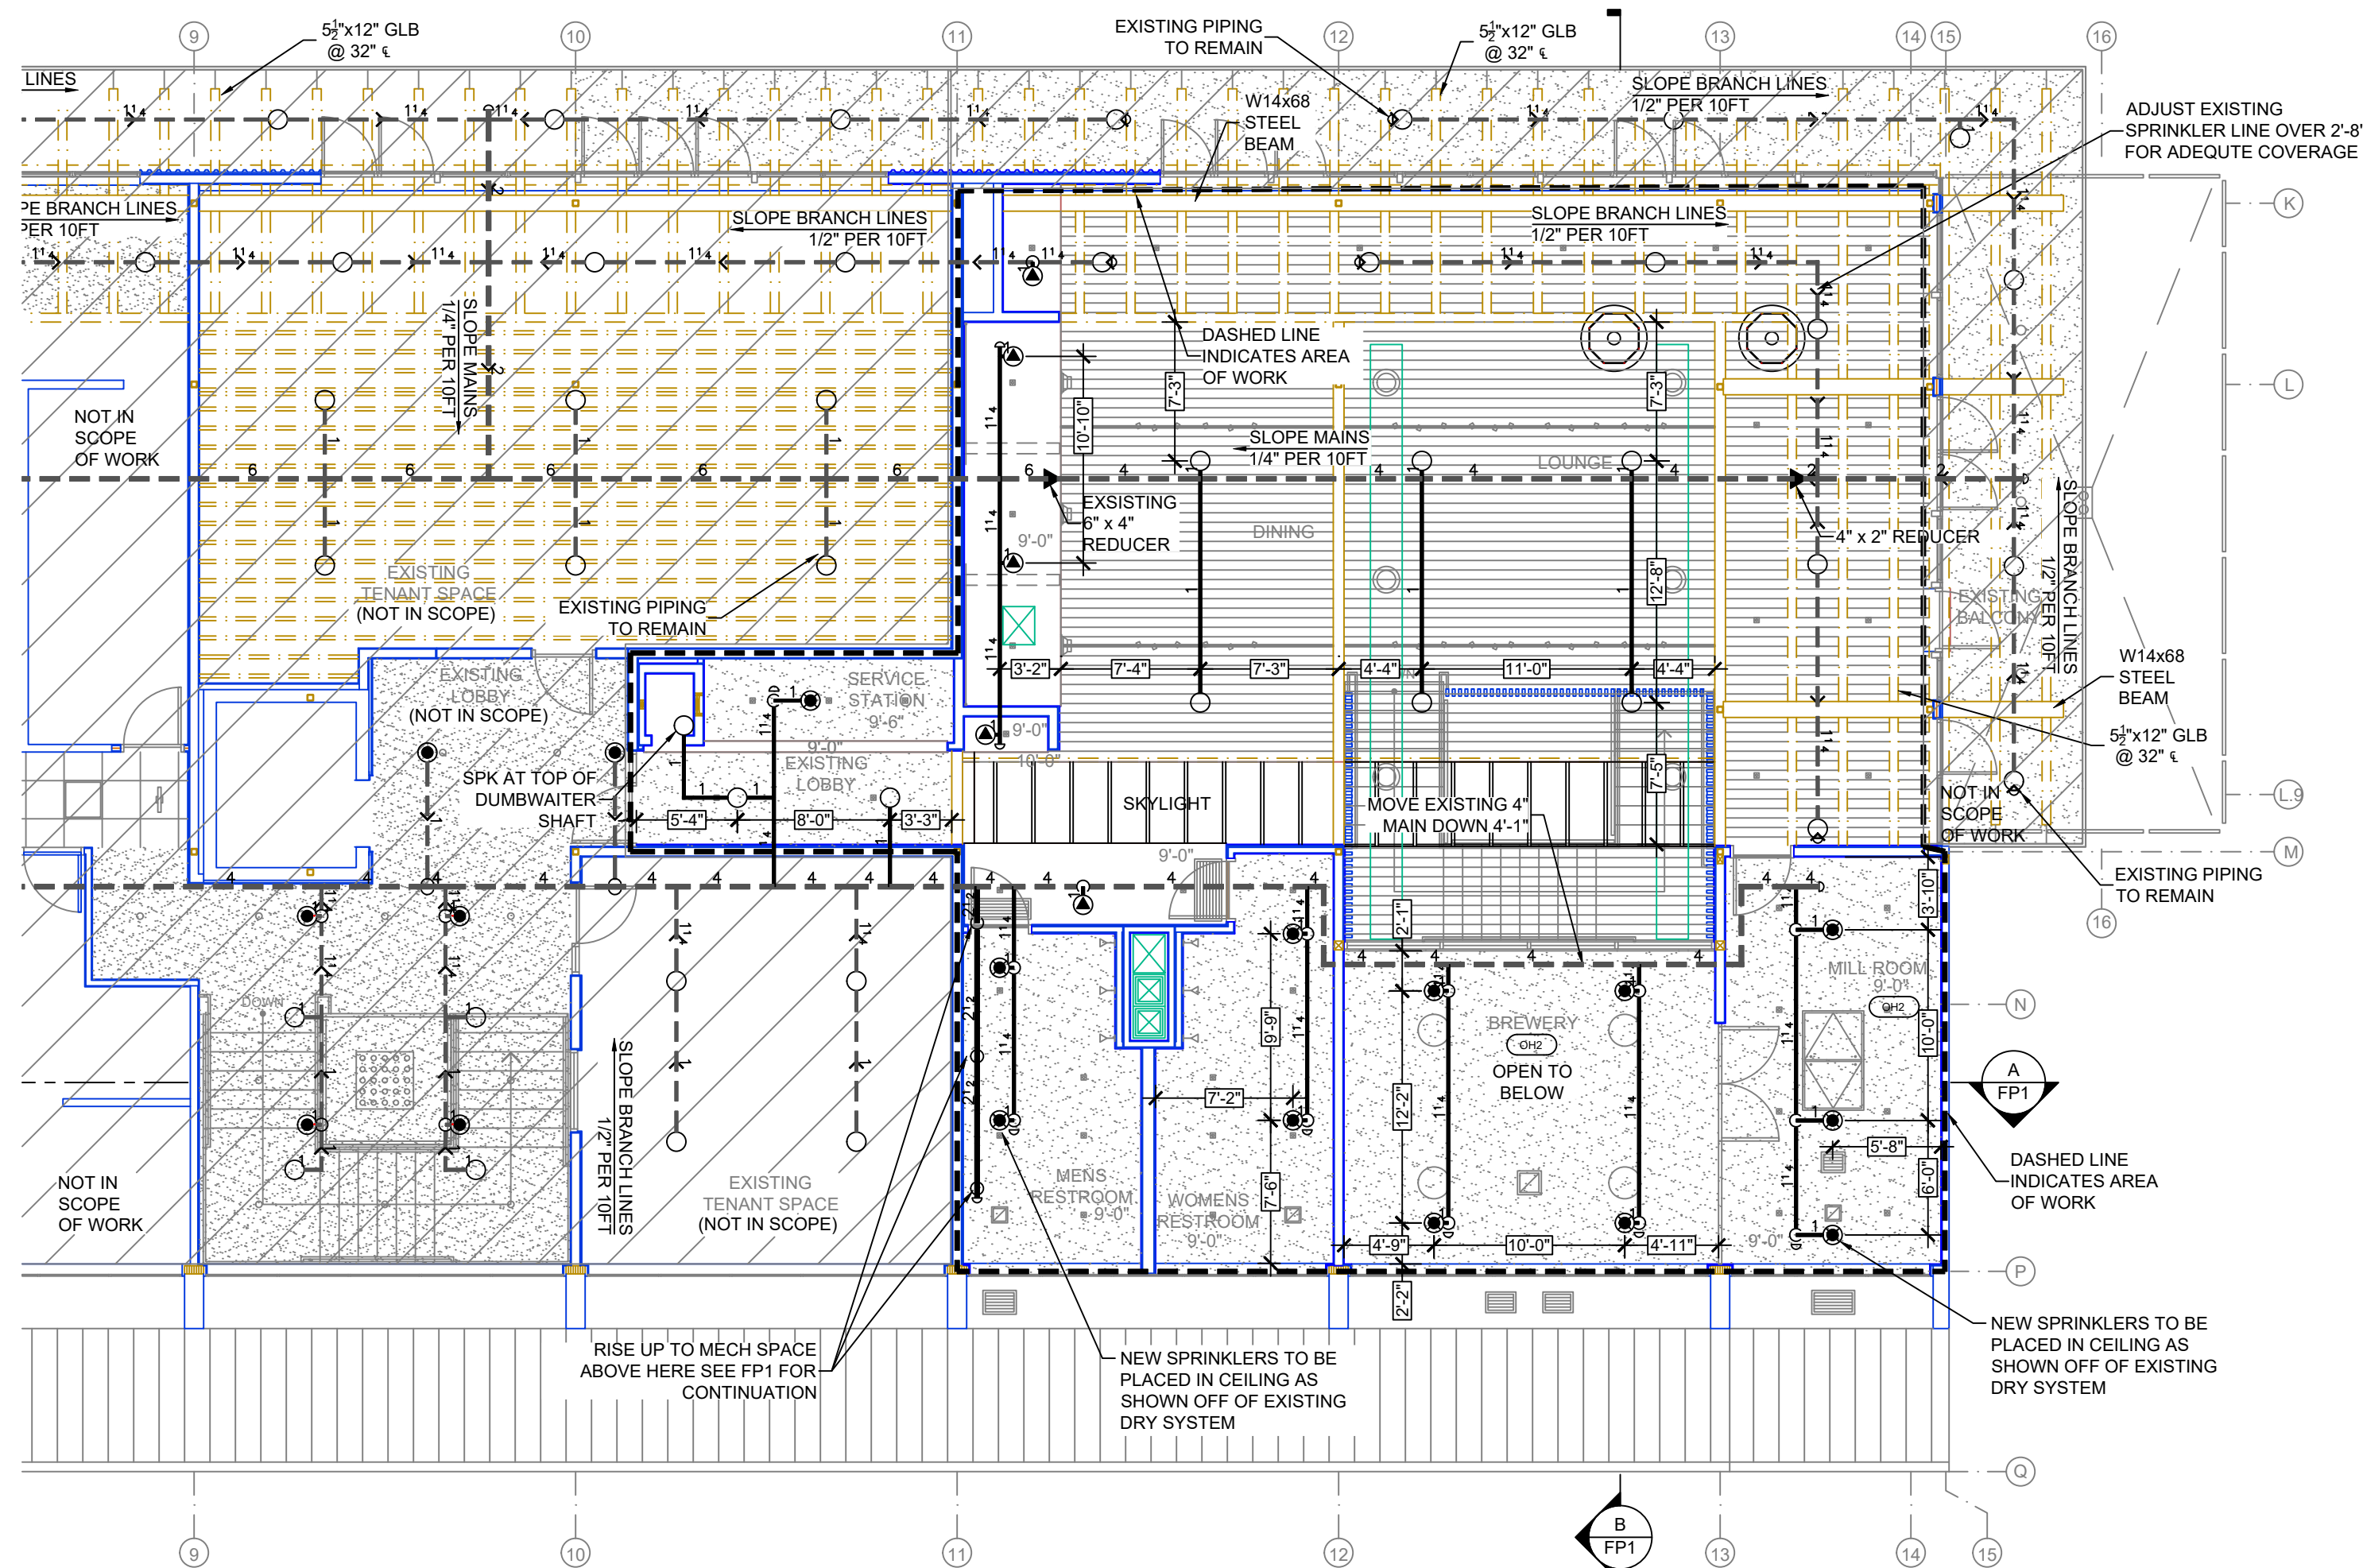

2ND FLOOR AREA B FIRE SPRINKLER PLAN
SCALE: 1/8" = 1'-0"

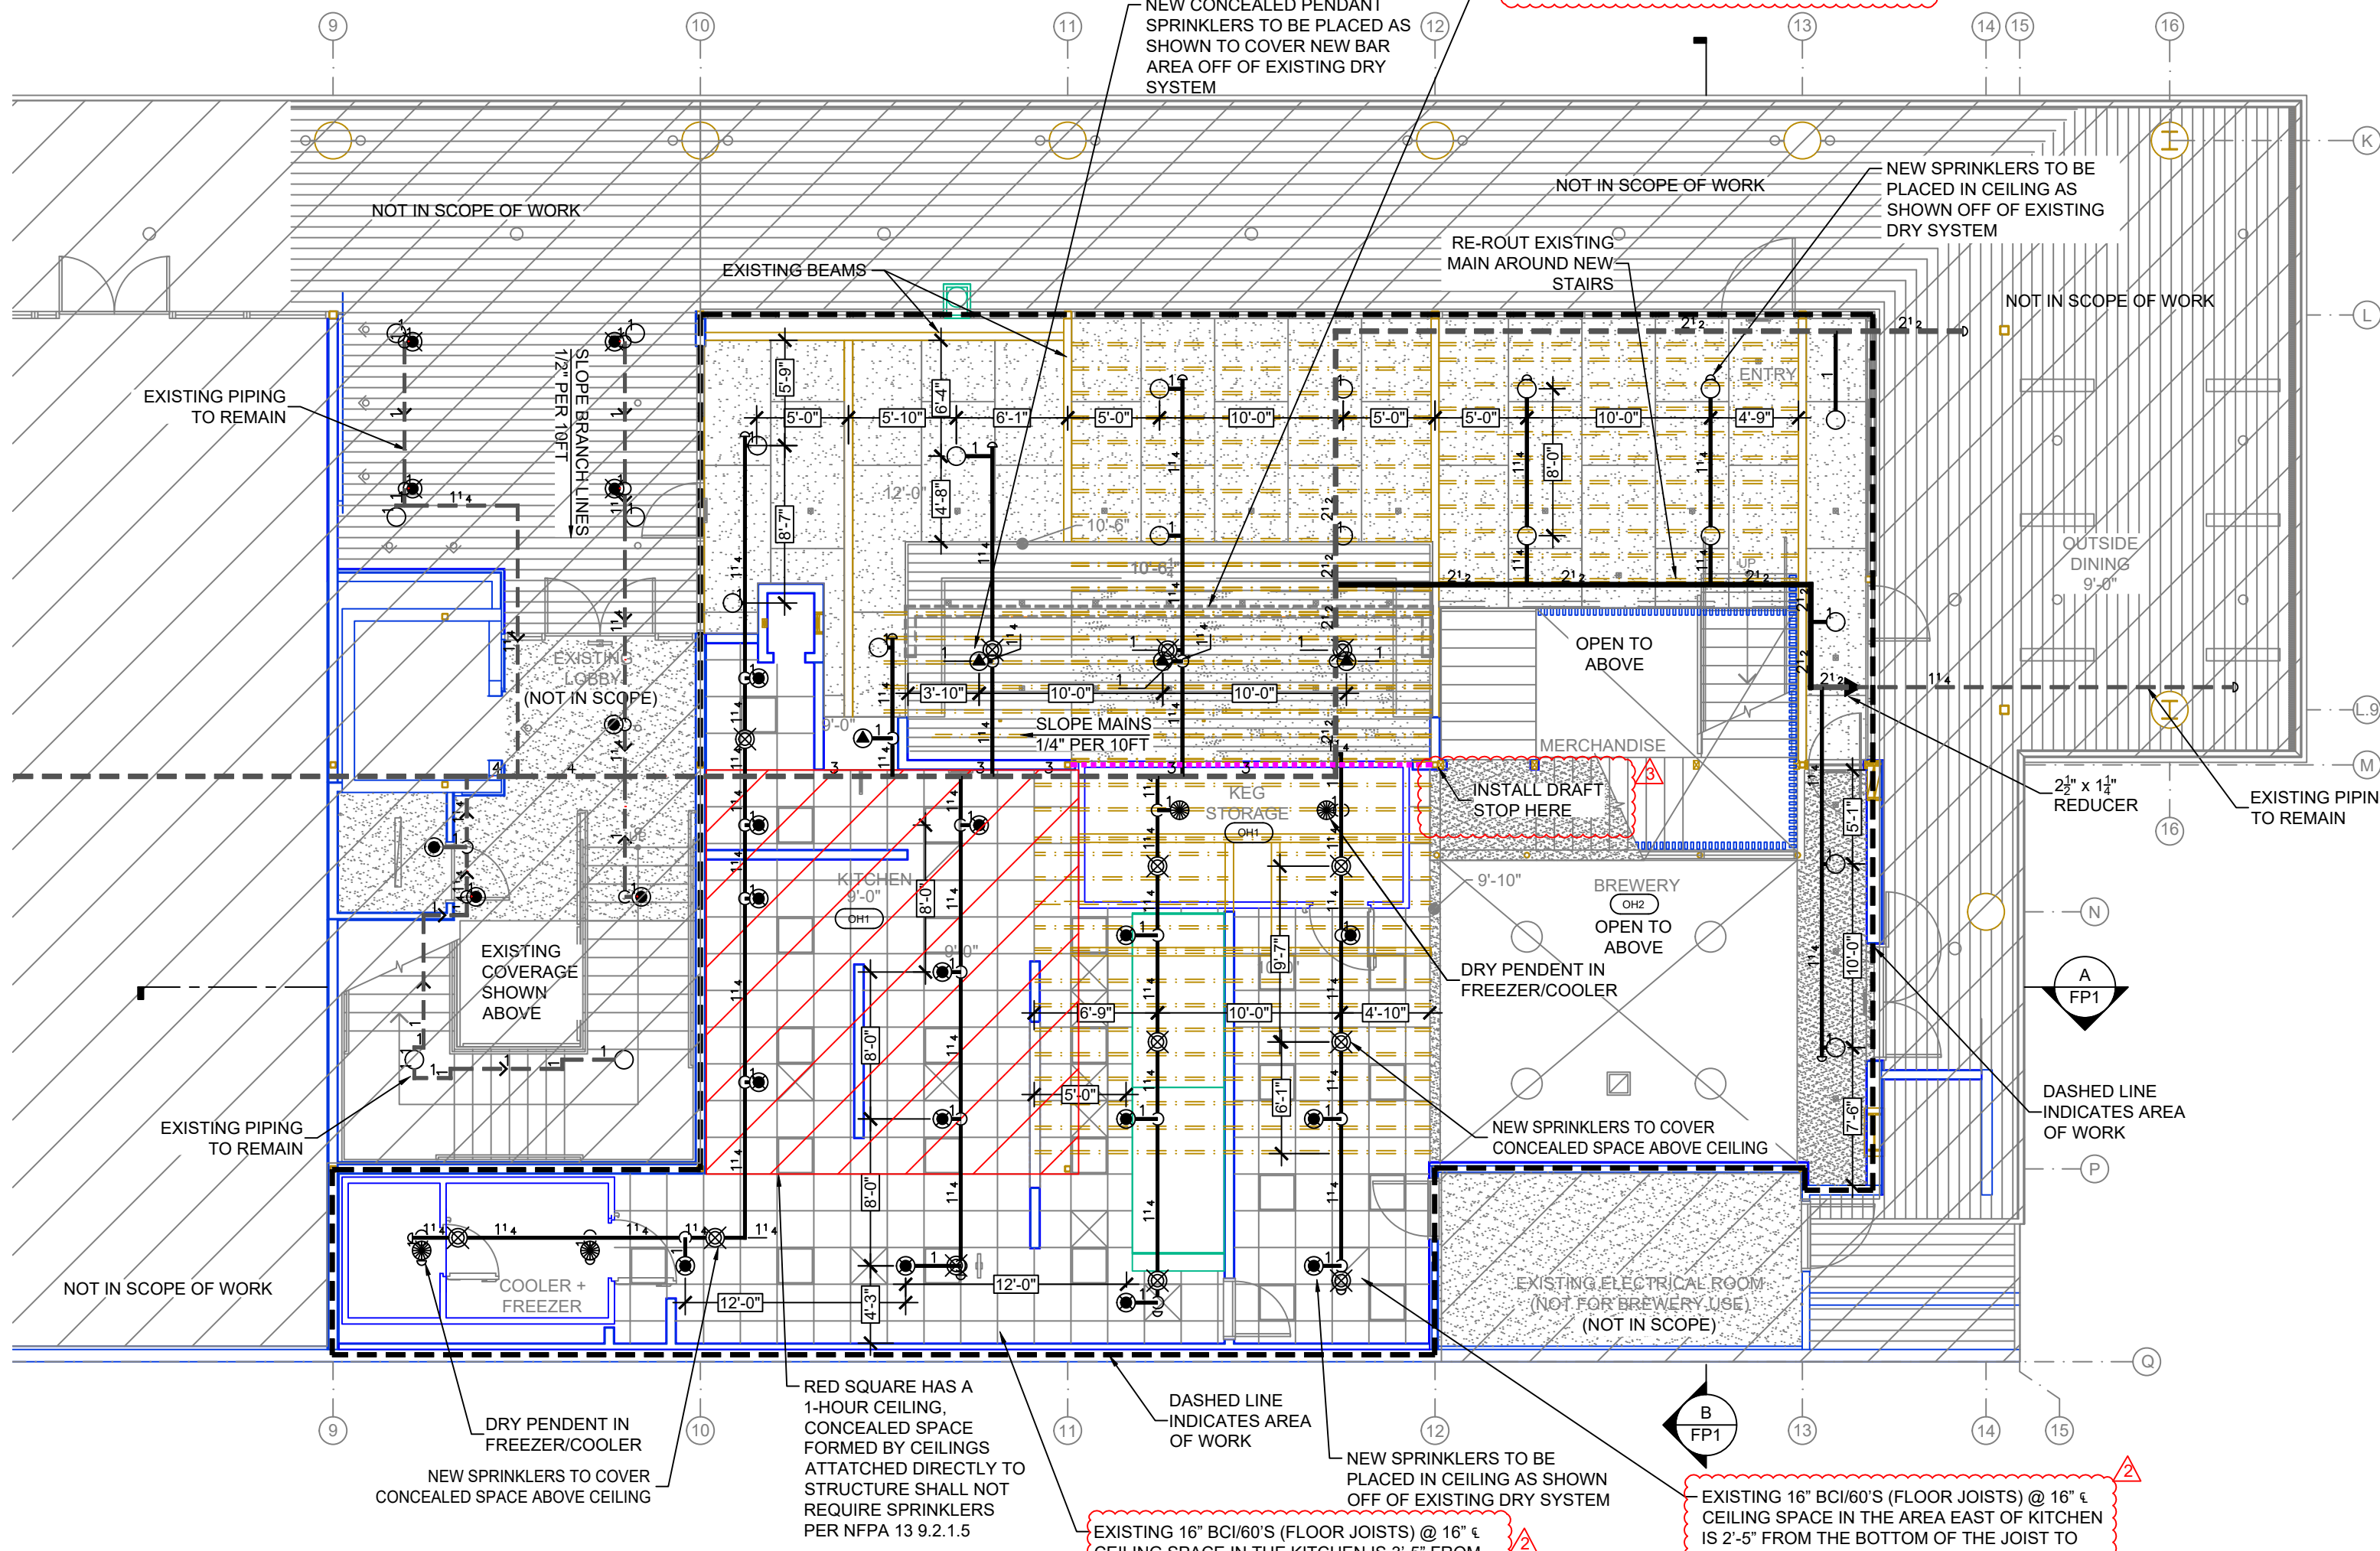

1ST FLOOR AREA B FIRE SPRINKLER PLAN
SCALE: 1/8" = 1'-0"

PIPE LEGEND
--- EXISTING DRY SYSTEM FIRE SPRINKLER PIPING
--- NEW DRY SYSTEM FIRE SPRINKLER PIPING


NO.	DATE	REVISIONS	DRAWN	CHECKED
3	10/23/25	PLAN REVIEW COMMENTS	BCJ	JV
2	10/1/25	PLAN REVIEW COMMENTS	BCJ	JV
1	9/12/25	PLAN REVIEW COMMENTS	BCJ	JV

GENERAL CONTRACTOR:	AUTHORITY HAVING JURISDICTION:
ADDRESS:	MAMMOTH LAKES FIRE DEPARTMENT
CITY:	ADDRESS: 3150 MAIN ST.
PHONE:	CITY: MAMMOTH LAKES, CA 93546
CONTACT:	PHONE: 760-934-2300
ARCHITECT:	CONTACT:
ADDRESS:	FIELD INSPECTIONS:
CITY:	1.
PHONE:	2.
	3.
	4.

SYM	QTY	TYPE	MFG.	MODEL#	NPT	K	TEMP	FINISH	S.I.
4	4	PENDANT	RELIABLE	F3QR56	1"	5.60	200°	401	R5714
27	27	PENDANT	RELIABLE	F1FR56	1/2"	5.60	200°	RECESSED	RA1414
13	13	UPRIGHT	VICTAULIC	FL-SA/IC	1/2"	5.60	200°	N/A	V5608
4	4	SIDEWALL	RELIABLE	F1FR56	1/2"	5.60	200°	N/A	RA1435
9	9	PENDANT	RELIABLE	G5-56	1/2"	5.60	165°	CONCEALED	RA3445
42	42	UPRIGHT	RELIABLE	F1FR56	1/2"	5.60	200°	N/A	RA1425

99 TOTAL NEW SPRINKLERS ON THIS JOB

FIRE SPRINKLER SYMBOLS	
⊗	AUTOMATIC SPRINKLER RISER
⊕	EARTHQUAKE BRACING
2-WAY & 4-WAY	CHANGE ELEVATION UP
PIPE HANGER & TYPE DESIGNATION	CHANGE ELEVATION DN
HYDRAULIC REF PT	INSPECTORS TEST
GRD OR THRD CAP	AUX DRAIN
GRD COUPLING	REVISION NOTATION
⊕	TYPICAL POINT OF CONNECTION (POC)
⊕	LOCAL ALARM

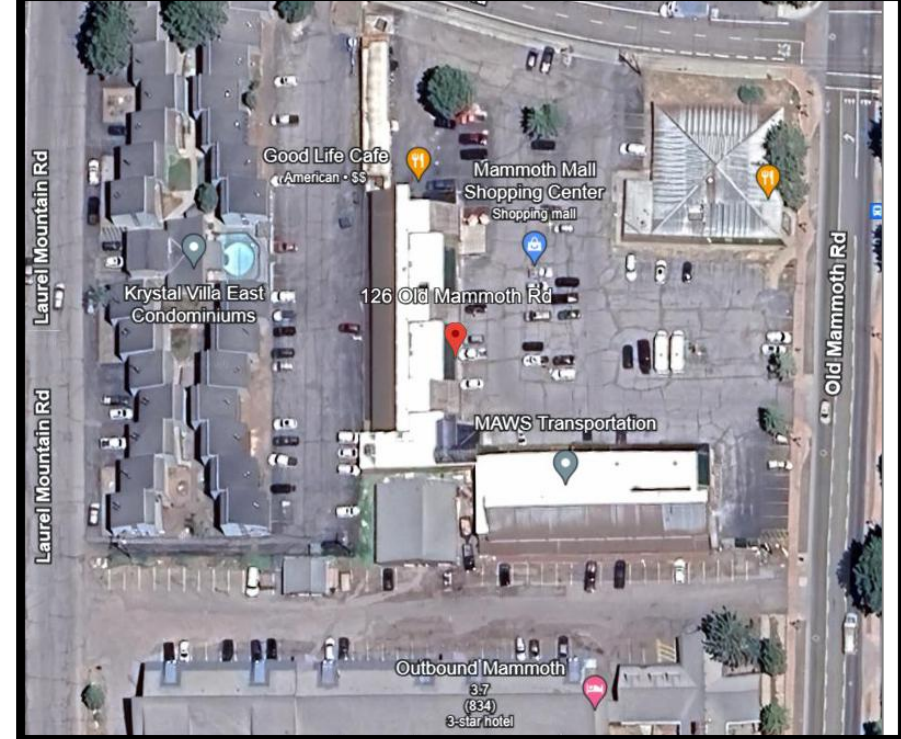

PROJECT NAME: FIRE SPRINKLER PLANS FOR
FIFTYFIFTY BREWING CO.
126 OLD MAMMOTH ROAD,
MAMMOTH LAKES, CA 93546

STAMP:

DRAWING TITLE:	FIRE SPRINKLER PLAN
SCALE: 1/8"=1'-0"	JOB NO.: 10/23/2025
DRAWN BY:	DWG NO.: FP-2
BORN ON DATE: 10/23/2025	SHEET 2 OF 2
FILE: 10/23/2025	